

A

B

C

D

E

F

G

H

A

B

C


D

E

F

G

H

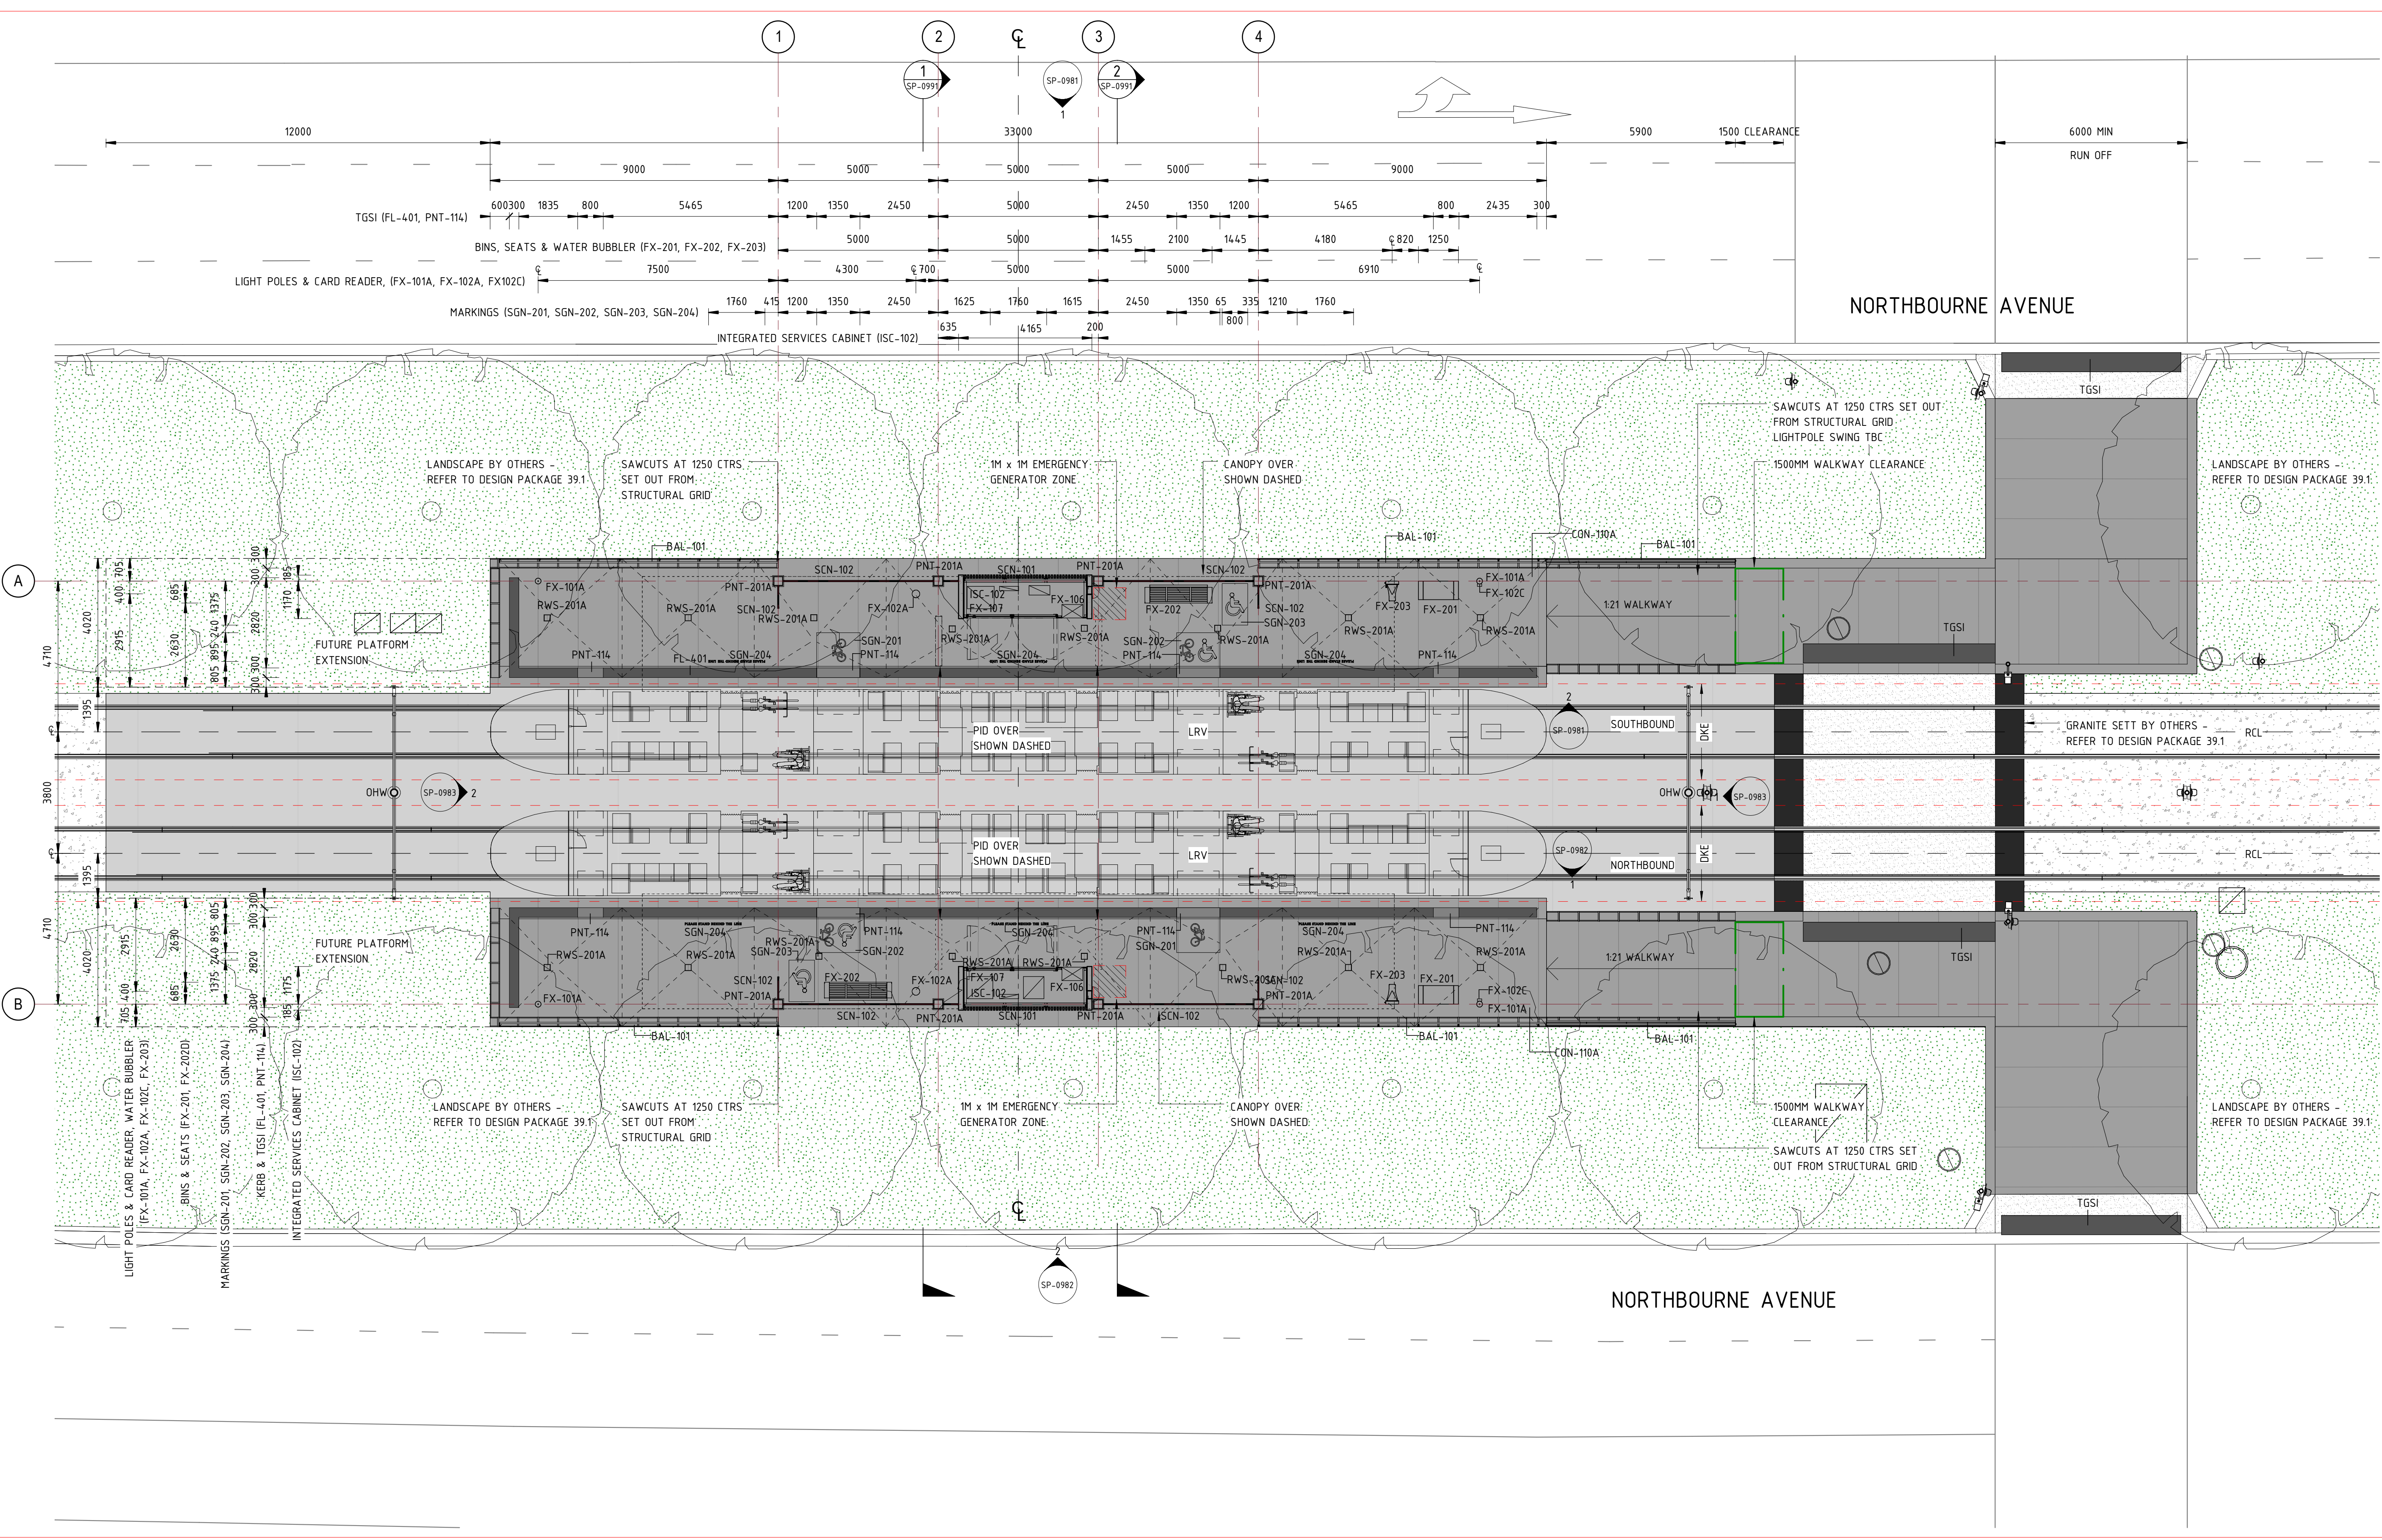

LEGEND

- STANDARD TRACKFORM
- COLOURED CONCRETE
- SOFT LANDSCAPING
- GRANITE SETTS
- WHITE CONCRETE
- BICYCLE LANE
- BUS STOP

NOTES

BICYCLE PARKING REFER TO DESIGN PACKAGE 39.1

ELECTRONIC TICKETING MACHINE & INTEGRATED SERVICES CABINETS ARE INDICATIVE ONLY & SUBJECT TO FURTHER INPUT FROM ENGINEERS &/OR THE TERRITORY

OHW LOCATIONS TBC. REFER TO DESIGN PACKAGE 38

PUBLIC DOMAIN TGSi SETOUT TBC. REFER TO DESIGN PACKAGE 39.1

STREET LIGHTING LOCATIONS TBC

TRAFFIC CONTROL DEVICES, SIGNS, LINES & ROAD MARKINGS TBC & COORDINATED

TRAFFIC BARRIER AT PHILLIP & SWINDEN TO BE CONFIRMED AND COORDINATED. REFER TO DESIGN PACKAGE 35

WALK UP AREAS TO BE SAW CUT COLOURED CONCRETE, REFER TO URBAN DESIGN PACKAGE 39.1


14:1 MAXIMUM PLATFORM CROSSFALL

CSR PIT LOCATIONS TBC

EXTENT & TYPE OF FLOOR FINISHES IN THE PUBLIC DOMAIN TBC. REFER TO DESIGN PACKAGE 39.1

NOT FOR CONSTRUCTION

STAGE 2R - 1

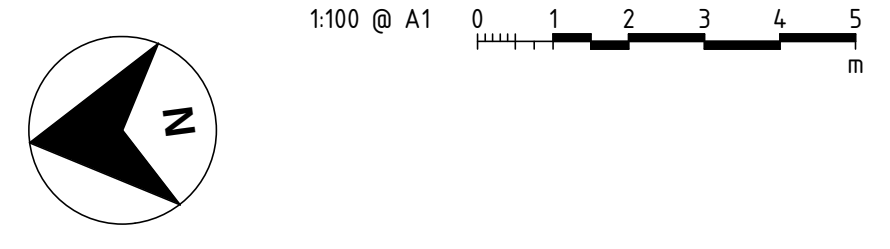

DRAWING COLOUR CODED - PRINT ALL COPIES IN COLOUR					
D	STAGE 2R-1 ISSUE	PJ 10/03	NJ 10/03	KC 10/03	
C	STAGE 2 ISSUE	PJ 20/12	NJ 20/12	KC 20/12	
B	STAGE 2 ISSUE	PJ 18/11	NJ 18/11	KC 18/11	
A	STAGE 1 ISSUE	SV 19/08	NJ 19/08	KC 19/08	
AMD	DESCRIPTION	DESIGNER SIGN / DATE	VERIFIED SIGN / DATE	APPROVED SIGN / DATE	
CO-ORDINATE SYSTEM: MGA Zone 56		HEIGHT DATUM: A.H.D.		SCALE: As indicated @ A1	



This drawing is confidential and shall only be used for the purpose of this project. The signing of this title block confirms the design and drafting of this project have been prepared and checked in accordance with the Architectus quality assurance system to ISO 9001-2008.

DRAWN	HH, KF, KW, PJ, RK, TT	-
DESIGNED	PHILLIP JI	-
DRG CHECK	KUSH VEHALLA	-
DESIGN CHECK	TRENT RUSSELL	-
APPROVED	KEVIN CARRUCAN	-

CAPITAL METRO PROJECT


PACKAGE 52 - FEDERAL HIGHWAY & NORTHBOURNE AVENUE STOPS

ARCHITECTURAL

DICKSON

GENERAL ARRANGEMENT PLAN



FILE No. 160117	SHEET: 1 OF 1	A1
STATUS: STAGE 2R - 1		
DRG No. 02-ARC-DRW-ARC-SP-0931	D	EDMS No.

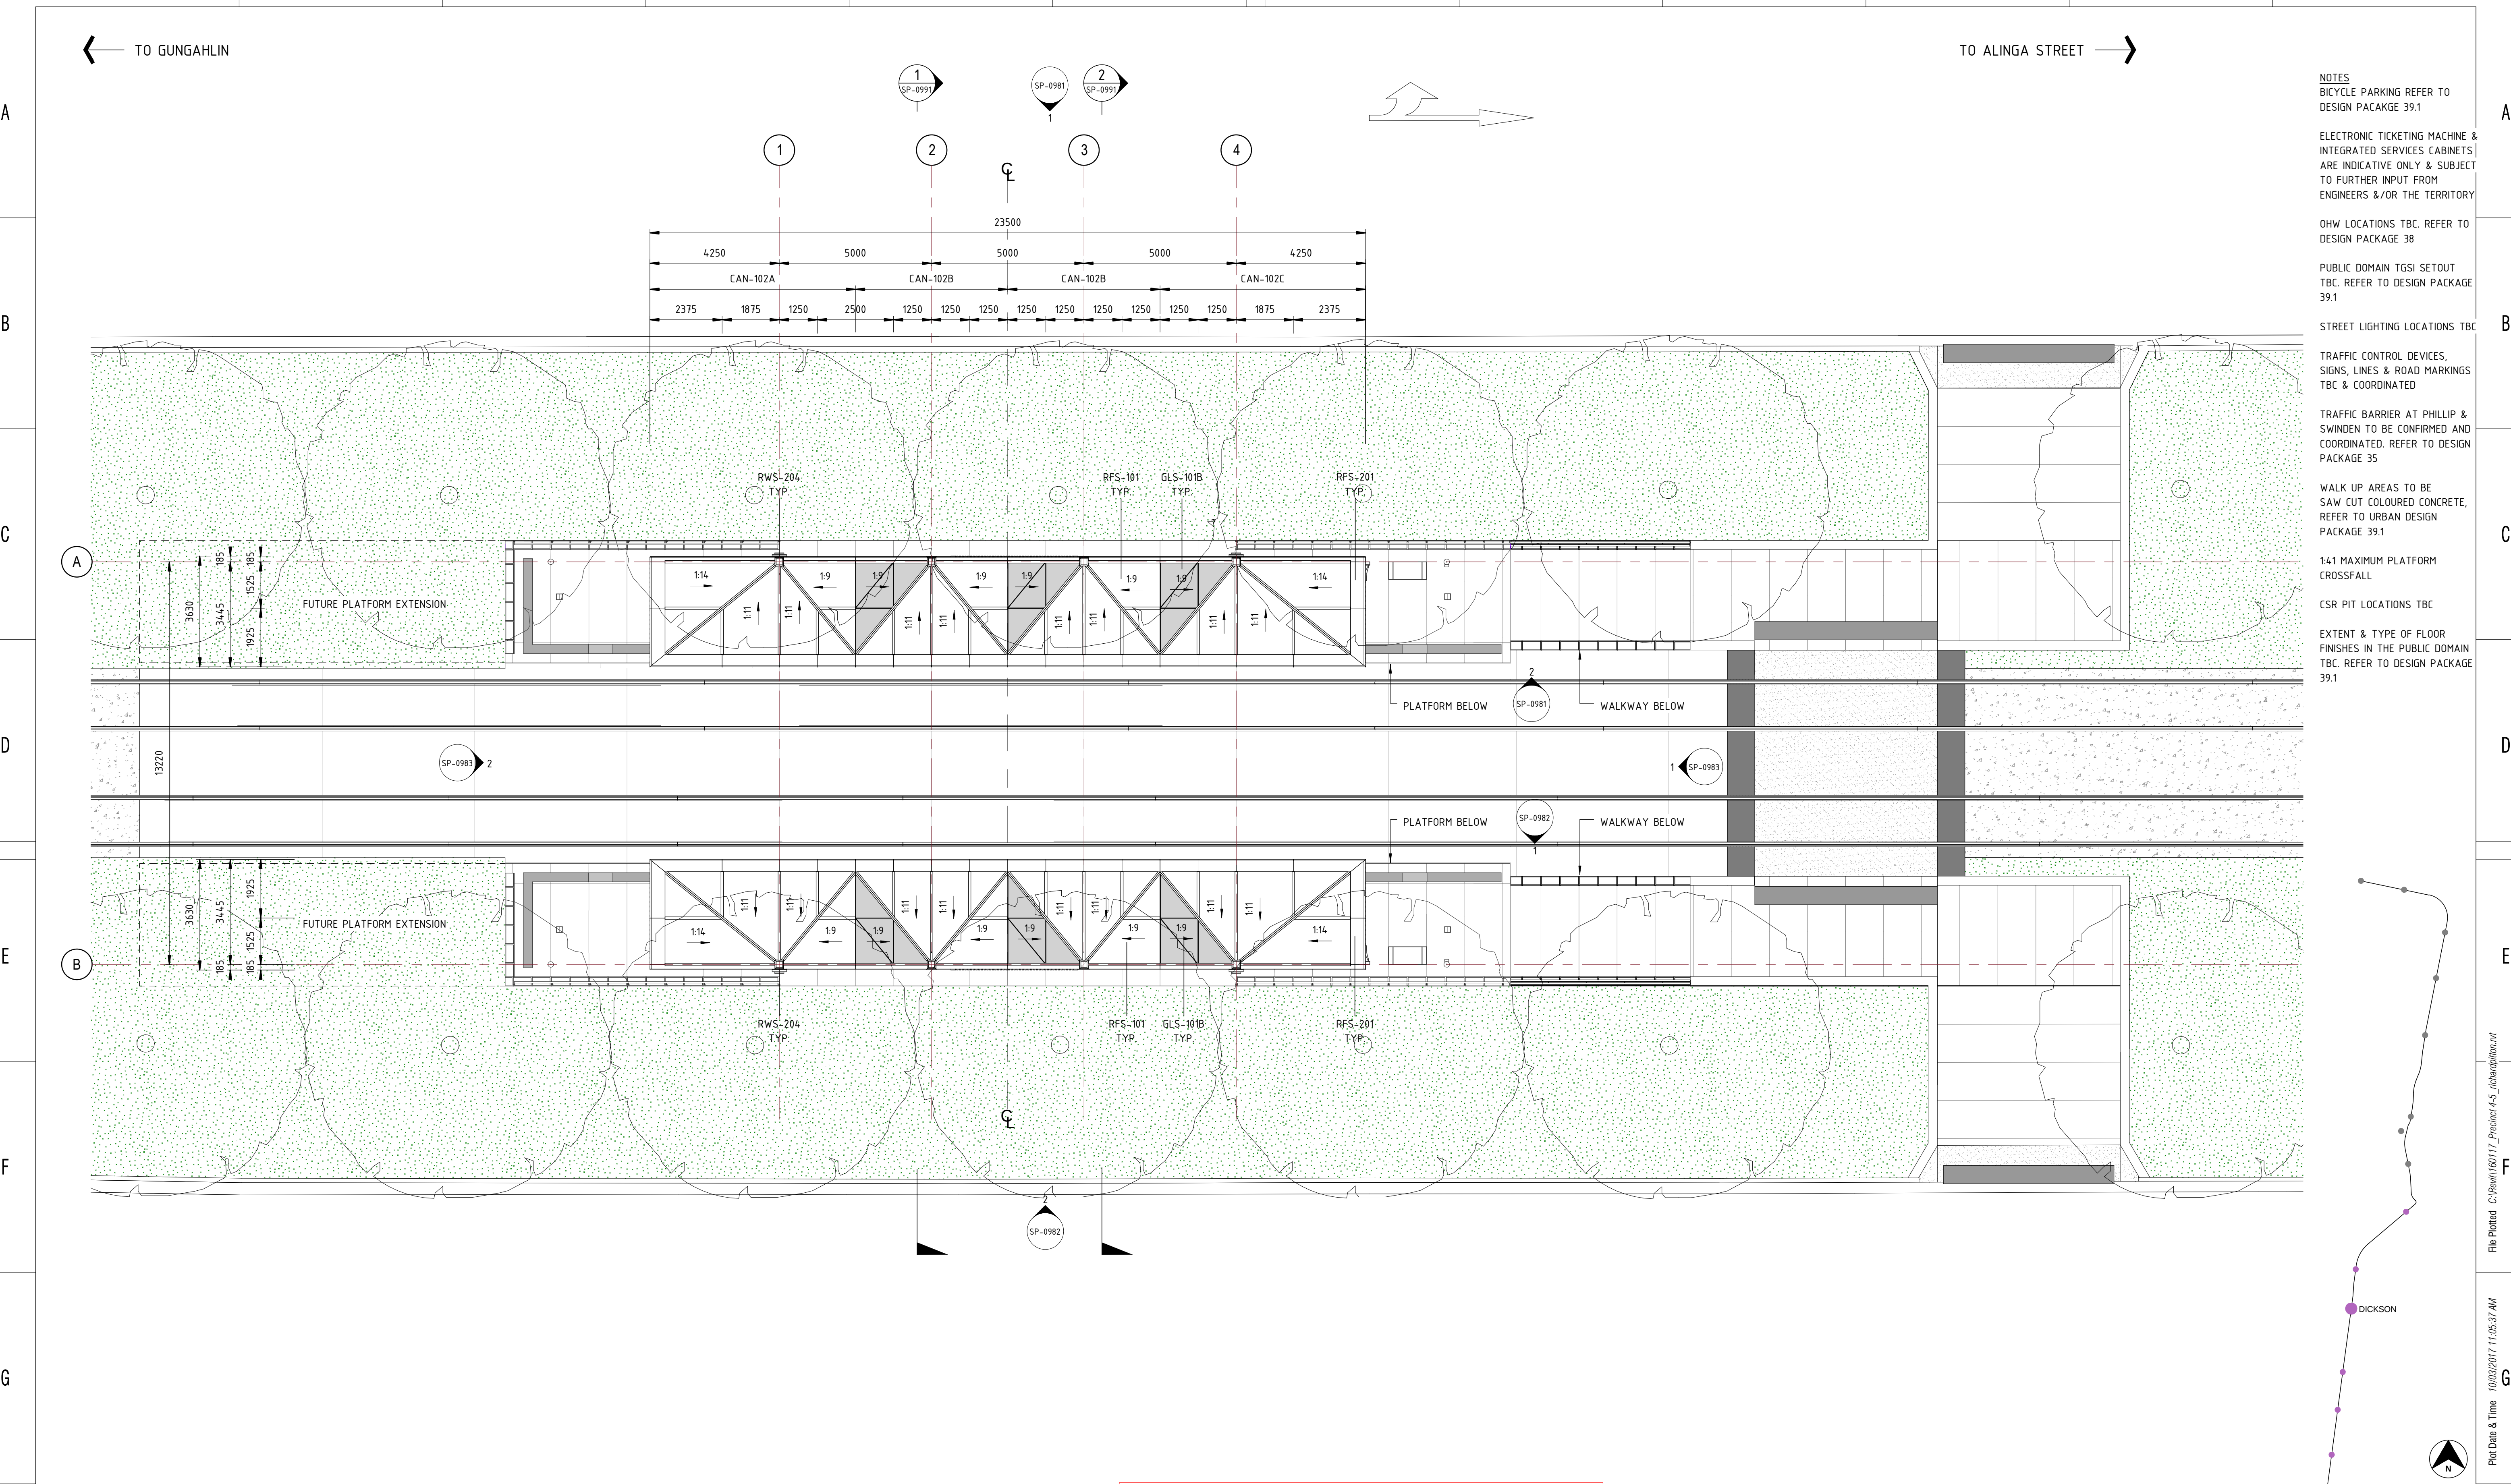

- NOTES
- BICYCLE PARKING REFER TO DESIGN PACKAGE 39.1
 - ELECTRONIC TICKETING MACHINE & INTEGRATED SERVICES CABINETS ARE INDICATIVE ONLY & SUBJECT TO FURTHER INPUT FROM ENGINEERS &/OR THE TERRITORY
 - OHW LOCATIONS TBC. REFER TO DESIGN PACKAGE 38
 - PUBLIC DOMAIN TGSi SETOUT TBC. REFER TO DESIGN PACKAGE 39.1
 - STREET LIGHTING LOCATIONS TBC
 - TRAFFIC CONTROL DEVICES, SIGNS, LINES & ROAD MARKINGS TBC & COORDINATED
 - TRAFFIC BARRIER AT PHILLIP & SWINDEN TO BE CONFIRMED AND COORDINATED. REFER TO DESIGN PACKAGE 35
 - WALK UP AREAS TO BE SAW CUT COLOURED CONCRETE. REFER TO URBAN DESIGN PACKAGE 39.1
 - 1:4:1 MAXIMUM PLATFORM CROSSFALL
 - CSR PIT LOCATIONS TBC
 - EXTENT & TYPE OF FLOOR FINISHES IN THE PUBLIC DOMAIN TBC. REFER TO DESIGN PACKAGE 39.1

DRAWING COLOUR CODED - PRINT ALL COPIES IN COLOUR

NOT FOR CONSTRUCTION
STAGE 2R - 1

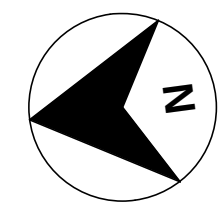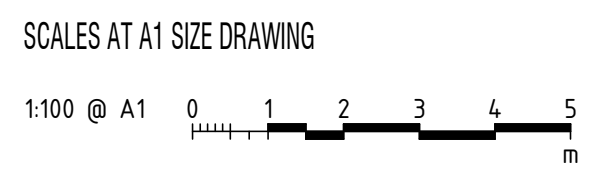

AMD	DESCRIPTION	DESIGNER SIGN / DATE	VERIFIED SIGN / DATE	APPROVED SIGN / DATE
D	STAGE 2R-1 ISSUE	PJ 10/03	NJ 10/03	KC 10/03
C	STAGE 2 ISSUE	PJ 20/12	NJ 20/12	KC 20/12
B	STAGE 2 ISSUE	PJ 18/11	NJ 18/11	KC 18/11
A	STAGE 1 ISSUE	SV 19/08	NJ 19/08	KC 19/08



This drawing is confidential and shall only be used for the purpose of this project. The signing of this title block confirms the design and drafting of this project have been prepared and checked in accordance with the Architectus quality assurance system to ISO 9001-2008.

architectus™

DRAWN _ HH, KF, KW, PJ, RK, TT _
DESIGNED _ PHILLIP JI _
DRG CHECK _ KUSH VEHALLA _
DESIGN CHECK _ TRENT RUSSELL _
APPROVED _ KEVIN CARRUCAN _

CAPITAL METRO PROJECT		
PACKAGE 52 - FEDERAL HIGHWAY & NORTHBOURNE AVENUE STOPS		
ARCHITECTURAL		
DICKSON		
ROOF PLAN		
FILE No. 160117	SHEET: 1 OF 1	A1
STATUS: STAGE 2R - 1		
DRG No. 02-ARC-DRW-ARC-SP-0941	D	EDMS No.

A

B

C

D

E

F

G

H

A

B

C

D

E

F

G


H

← TO GUNGAHLIN

TO ALINGA STREET →



Note:

- RAINWATER OUTLETS FINAL LOCATIONS WILL REQUIRE COORDINATION TO FOOTINGS
- FOOTING SIZES AND SETOUTS TO BE CONFIRMED
- INTEGRATED SERVICES CABINET SIZE TBC BY TYCO. LOCATION OF RWO IN SERVICE PIT (IF ANY) TBC BY TYCO.
- PLATFORM SAWCUTS TO ALIGN WITH SAWCUTS IN THE COLOURED CONCRETE TRACKFORM. REFER TO DESIGN PACKAGE 39.1.
- HEARING LOOP SET OUT TO BE CONFIRMED BY SMEC REFER TO DESIGN PACKAGE 62
- SMEC TO COORDINATE HEARING LOOP WITH RAINWATER OUTLET AND SAWCUTS.

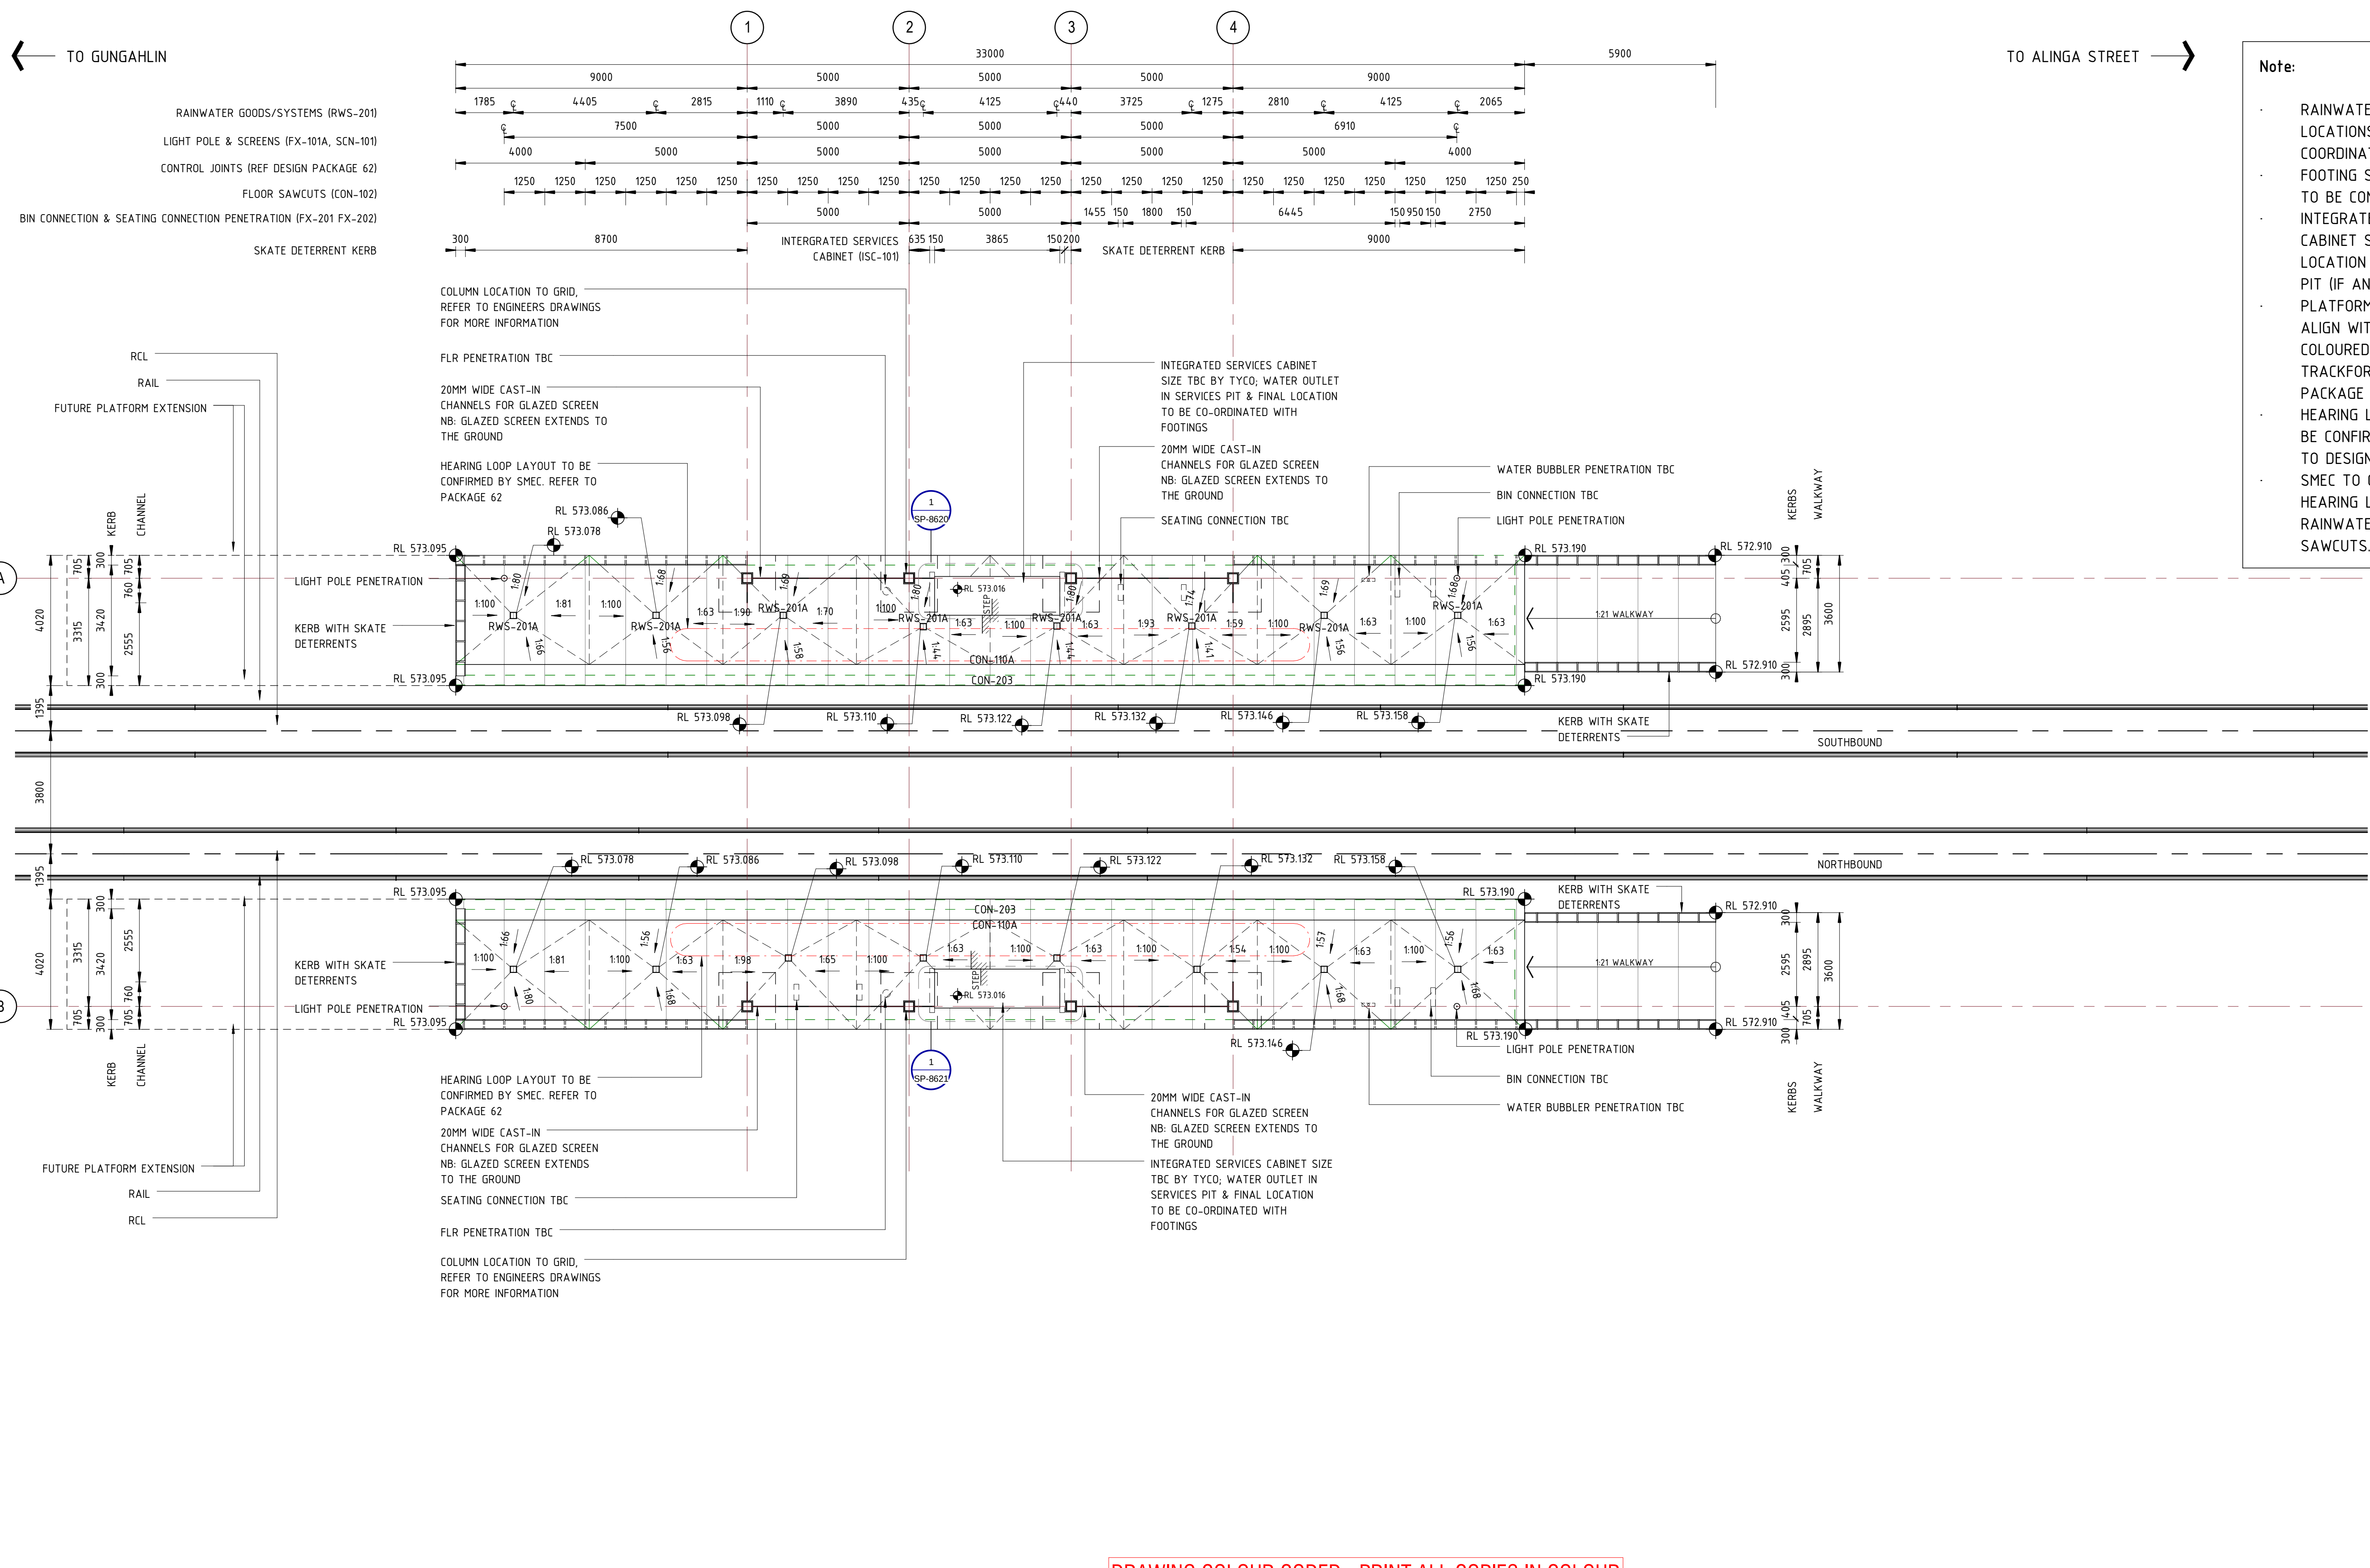

NOT FOR CONSTRUCTION

STAGE 2R - 1

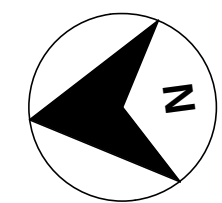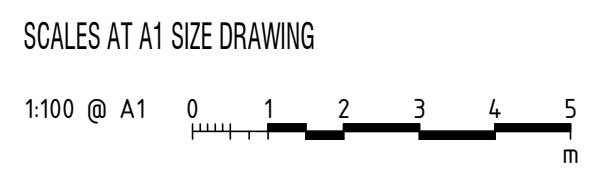

DRAWING COLOUR CODED - PRINT ALL COPIES IN COLOUR


C	STAGE 2R-1 ISSUE	PJ 10/03	NJ 10/03	KC 10/03
B	STAGE 2 ISSUE	PJ 20/12	NJ 20/12	KC 20/12
A	STAGE 2 ISSUE	PJ 18/11	NJ 18/11	KC 18/11
AMD	DESCRIPTION	DESIGNER SIGN / DATE	VERIFIED SIGN / DATE	APPROVED SIGN / DATE
CO-ORDINATE SYSTEM: MGA Zone 56		HEIGHT DATUM: A.H.D.		SCALE: 1:100 @ A1



This drawing is confidential and shall only be used for the purpose of this project. The signing of this title block confirms the design and drafting of this project have been prepared and checked in accordance with the Architectus quality assurance system to ISO 9001-2008.



DRAWN	TT, EL, PJ	-
DESIGNED	PHILLIP JI	-
DRG CHECK	KUSH VEHALLA	-
DESIGN CHECK	TRENT RUSSELL	-
APPROVED	KEVIN CARRUCAN	-

CAPITAL METRO PROJECT		
PACKAGE 52 - FEDERAL HIGHWAY & NORTHBOURNE AVENUE STOPS		
ARCHITECTURAL		
DICKSON		
CONCRETE SETOUT PLAN		
FILE No. 160117	SHEET: 1 OF 1	A1
STATUS: STAGE 2R - 1		
DRG No. 02-ARC-DRW-ARC-SP-0951	C	EDMS No.

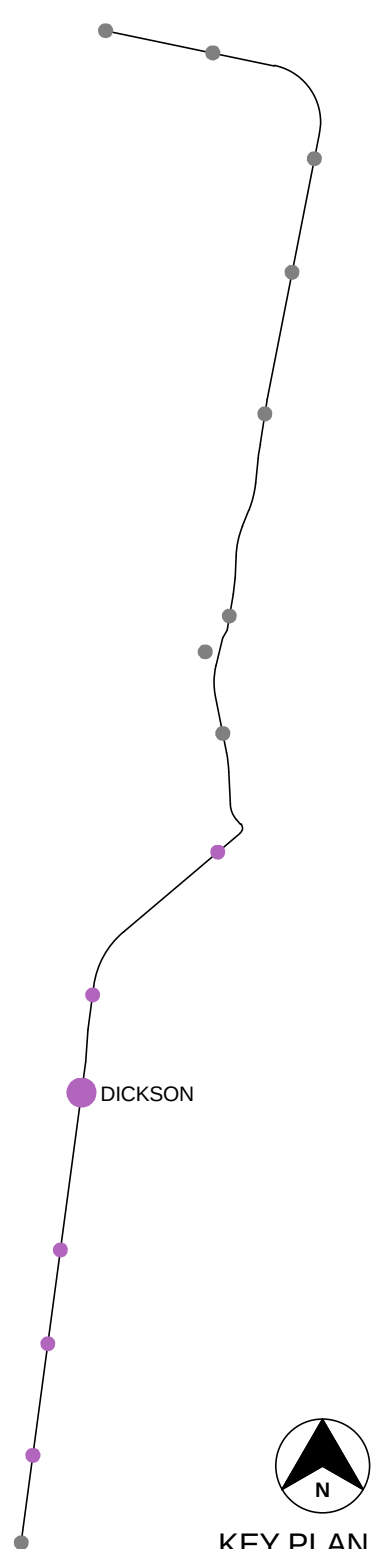


← TO GUNGAHLIN

TO ALINGA STREET →

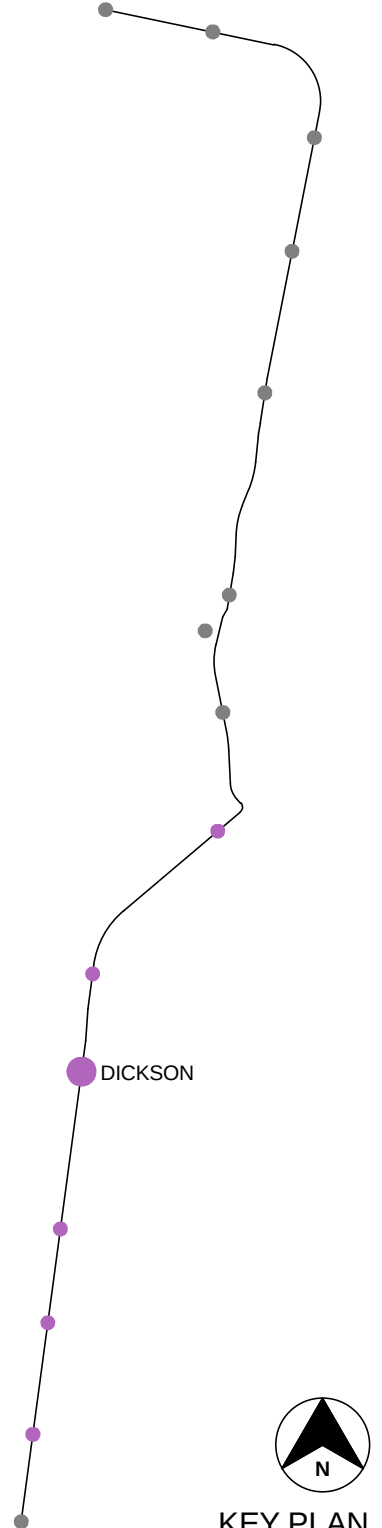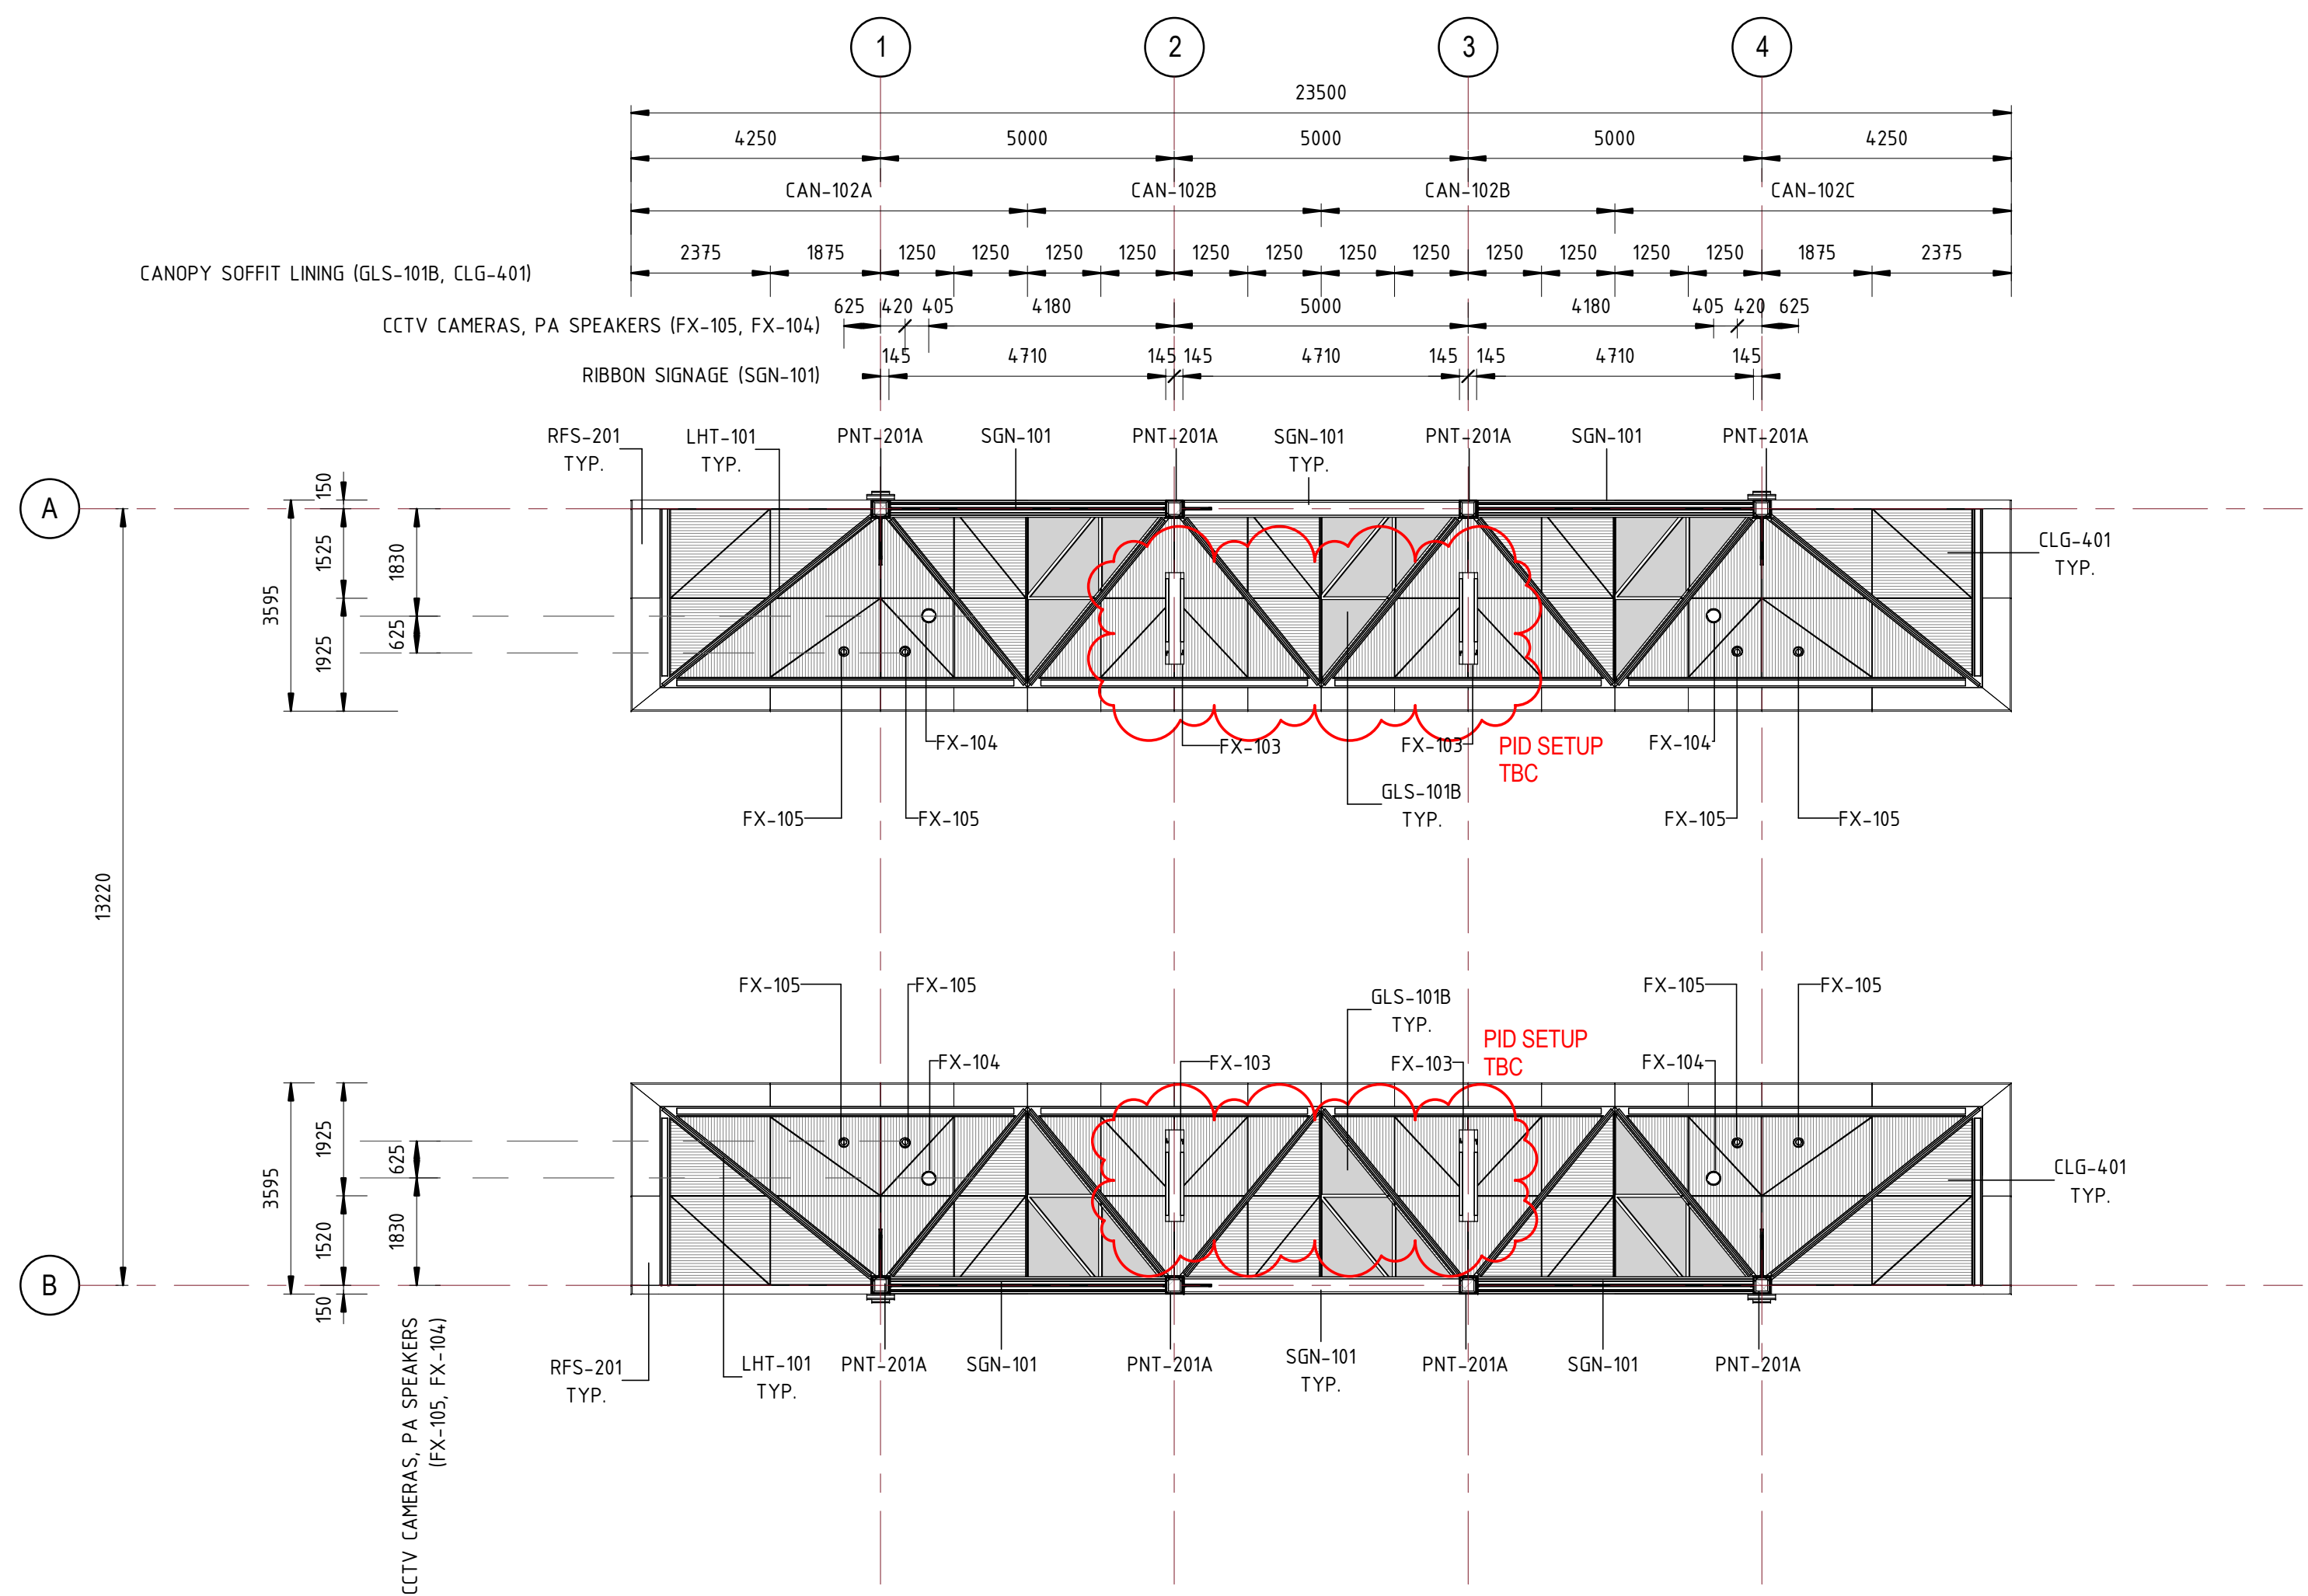

**NOT FOR
CONSTRUCTION**
STAGE 2R - 1

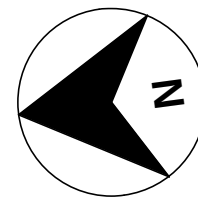

SCALES AT A1 SIZE DRAWING

1:100 @ A1 0 1 2 3 4 5 m

REV	DESCRIPTION	DESIGNER	VERIFIED	APPROVED
C	STAGE 2R-1 ISSUE	PJ 10/03	NJ 10/03	KC 10/03
B	STAGE 2 ISSUE	PJ 20/12	NJ 20/12	KC 20/12
A	STAGE 2 ISSUE	PJ 18/11	NJ 18/11	KC 18/11
AMD	DESCRIPTION	DESIGNER SIGN / DATE	VERIFIED SIGN / DATE	APPROVED SIGN / DATE
CO-ORDINATE SYSTEM: MGA Zone 56		HEIGHT DATUM: A.H.D.		SCALE: 1:100 @ A1

CapitalMetro
ACT Government

CANBERRA
METRO
Move | Live | Grow

This drawing is confidential and shall only be used for the purpose of this project.
The signing of this title block confirms the design and drafting of this project have been prepared
and checked in accordance with the Architectus quality assurance system to ISO 9001-2008.

architectus™

DRAWN _ TT, EL, PJ _ _ _ _ _
DESIGNED _ PHILLIP JI _ _ _ _ _
DRG CHECK _ KUSH VEHALLA _ _ _ _ _
DESIGN CHECK _ TRENT RUSSELL _ _ _ _ _
APPROVED _ KEVIN CARRUCAN _ _ _ _ _

CAPITAL METRO PROJECT		
PACKAGE 52 - FEDERAL HIGHWAY & NORTHBOURNE AVENUE STOPS		
ARCHITECTURAL		
DICKSON		
REFLECTED CEILING PLAN		
FILE No. 160117	SHEET: 1 OF 1	A1
STATUS: STAGE 2R - 1		
DRG No. 02-ARC-DRW-ARC-SP-0961	C	EDMS No.



KEY PLAN

File Printed: C:\Bev\160117_Prelim 4-5_inch.dwg


Plot Date & Time: 10/03/2017 12:10:04 PM

DR 801*554

DICKSON ELEVATION

SCALE: 1 : 100 @ A1

1
SP-0931

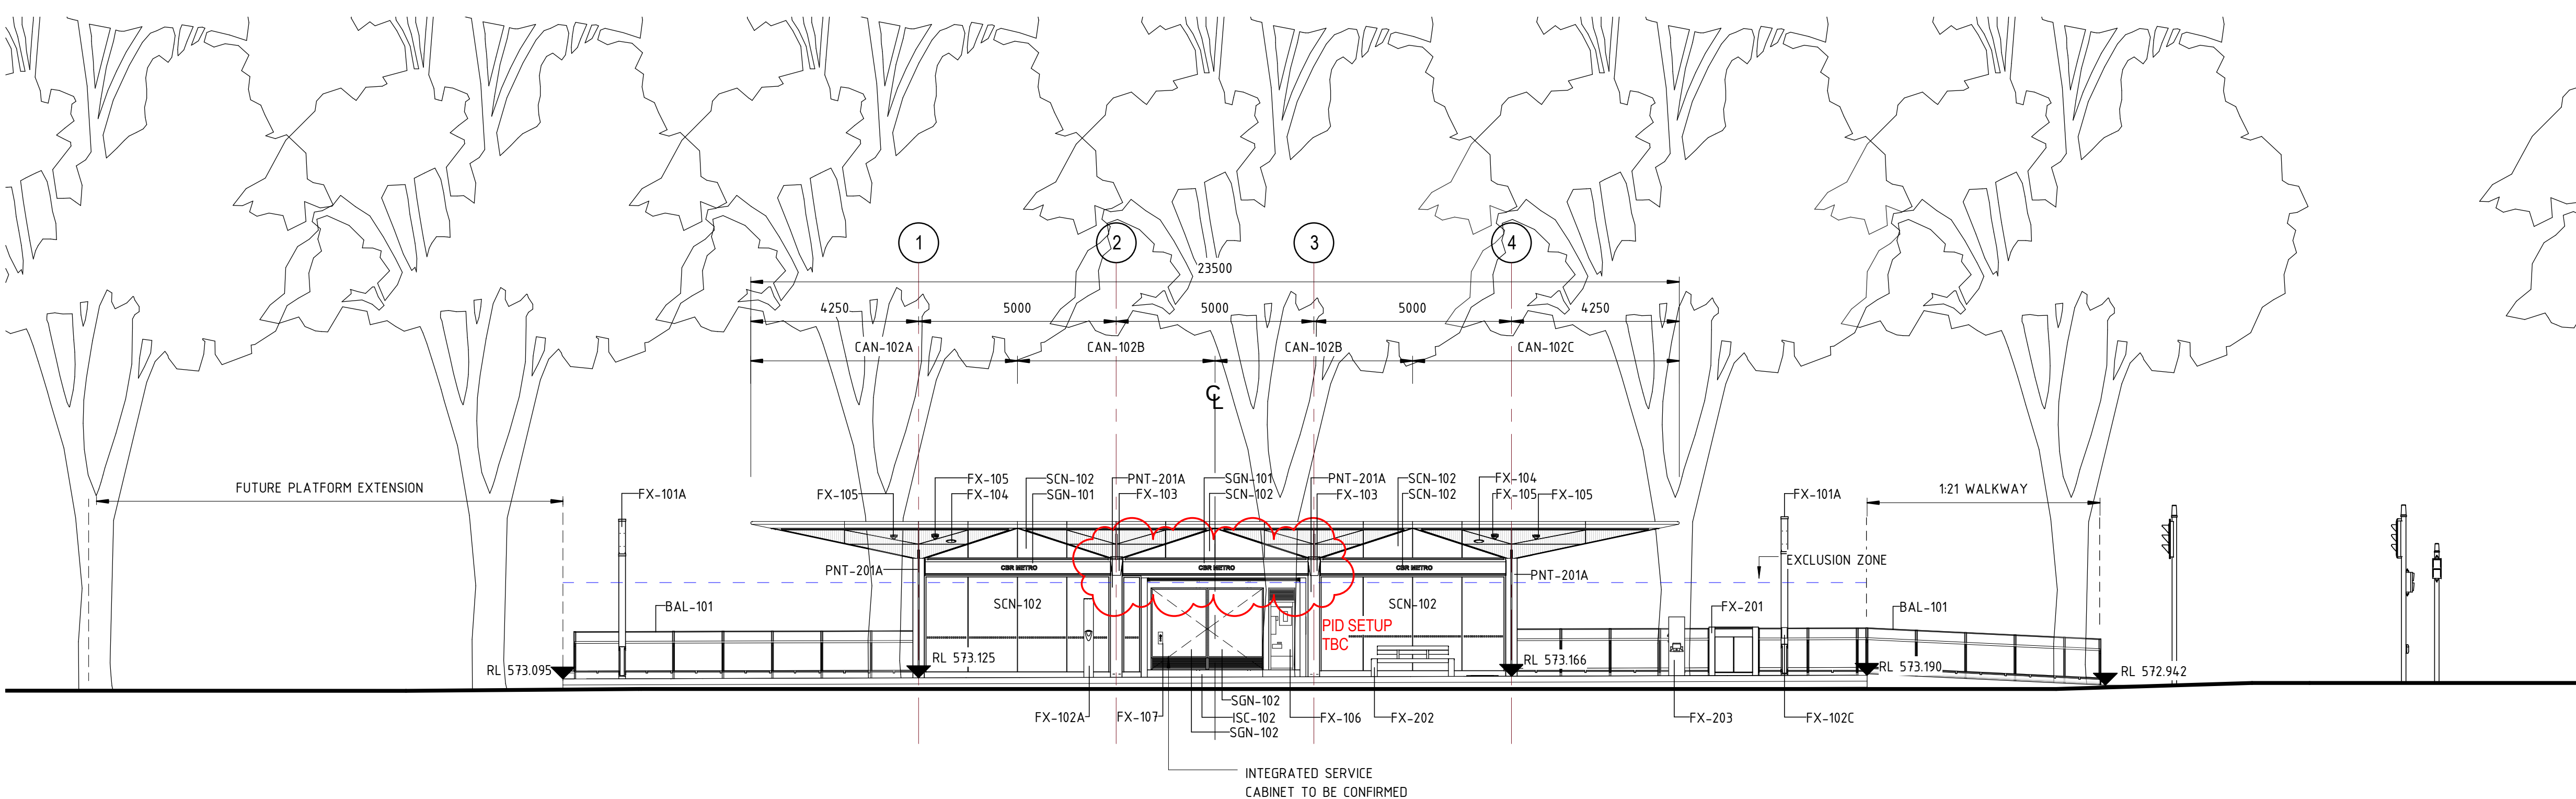

DICKSON ELEVATION

SCALE: 1 : 100 @ A1

2
SP-0931

**NOT FOR
CONSTRUCTION**

STAGE 2R - 1

SCALES AT A1 SIZE DRAWING



DRAWING COLOUR CODED - PRINT ALL COPIES IN COLOUR

NO.	DESCRIPTION	DESIGNER SIGN / DATE	VERIFIED SIGN / DATE	APPROVED SIGN / DATE
D	STAGE 2R-1 ISSUE	PJ 10/03	NJ 10/03	KC 10/03
C	STAGE 2 ISSUE	PJ 20/12	NJ 20/12	KC 20/12
B	STAGE 2 ISSUE	PJ 18/11	NJ 18/11	KC 18/11
A	STAGE 1 ISSUE	SV 19/08	NJ 19/08	KC 19/08
AMD				
CO-ORDINATE SYSTEM: MGA Zone 56		HEIGHT DATUM: A.H.D.		SCALE: 1 : 100 @ A1

CapitalMetro
ACT Government

CANBERRA
METRO
Move | Live | Grow

This drawing is confidential and shall only be used for the purpose of this project.
The signing of this title block confirms the design and drafting of this project have been prepared and checked in accordance with the Architectus quality assurance system to ISO 9001-2008.

architectus™

DRAWN _ HH, KF, KW, PJ, RK, TT
DESIGNED _ PHILLIP JI
DRG CHECK _ KUSH VEHALLA
DESIGN CHECK _ TRENT RUSSELL
APPROVED _ KEVIN CARRUCAN

CAPITAL METRO PROJECT
PACKAGE 52 - FEDERAL HIGHWAY & NORTHBOURNE AVENUE STOPS
ARCHITECTURAL
DICKSON
ELEVATIONS - SHEET 1

FILE No. 160117	SHEET: 1 OF 3	A1
STATUS: STAGE 2R - 1		
DRG No. 02-ARC-DRW-ARC-SP-0981	D	EDMS No.




KEY PLAN

File Path: C:\Bevel\160117_Prelim\4-5_inch\architectus.rvt

Plot Date & Time 10/03/2017 11:05:52 AM



H

OF 801*554

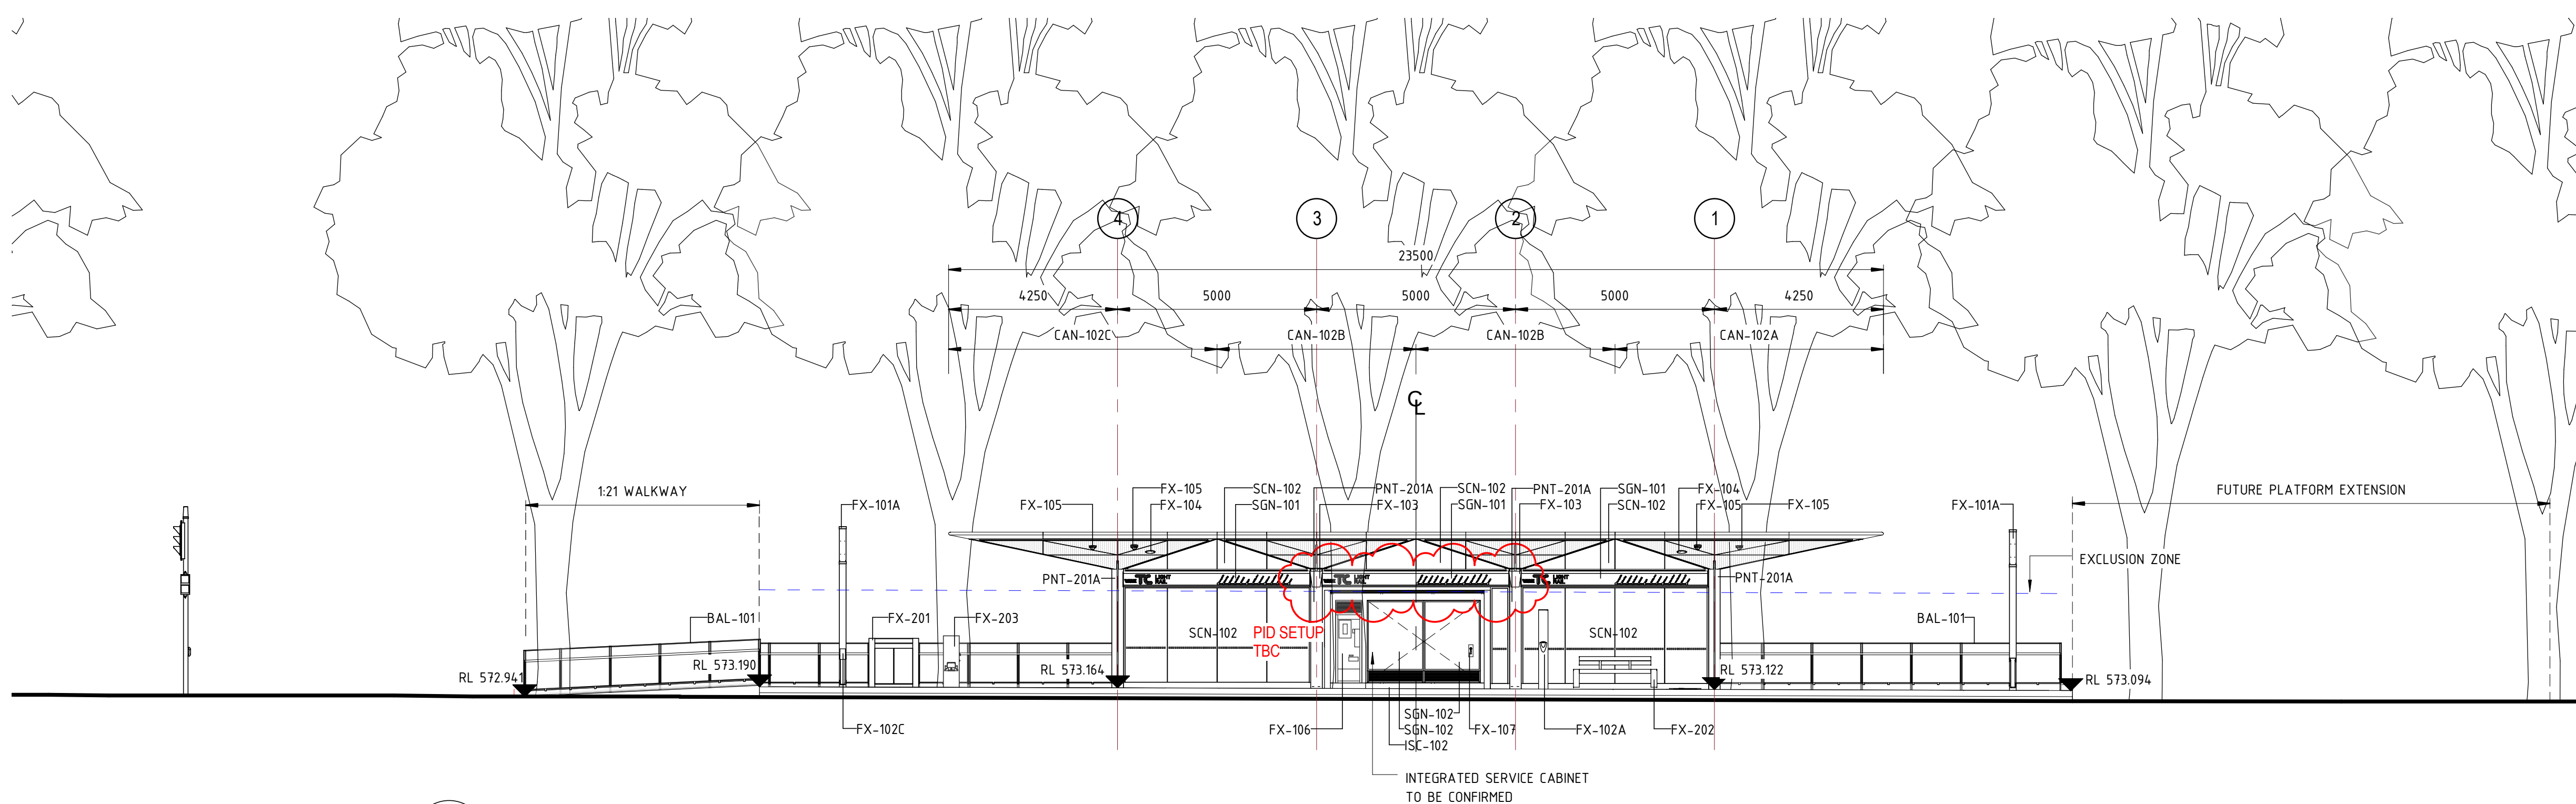


DICKSON ELEVATION

SCALE: 1 : 100 @ A1

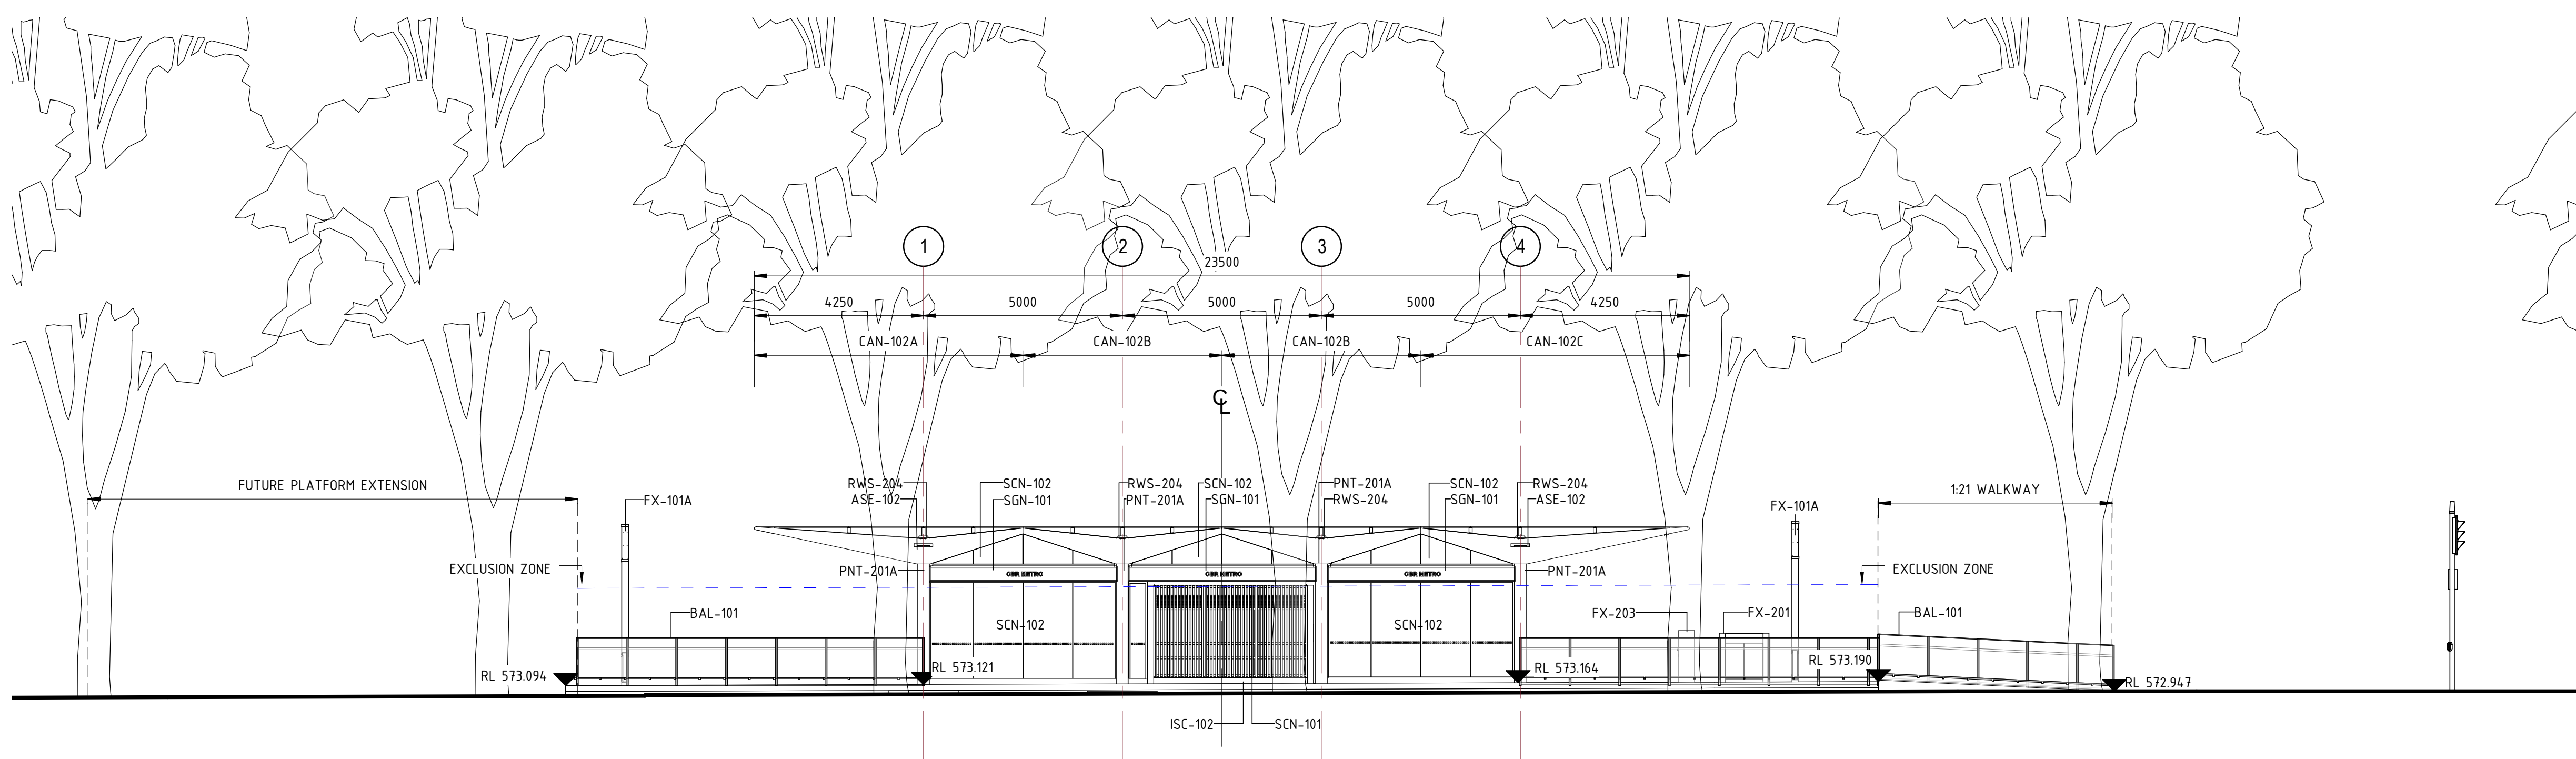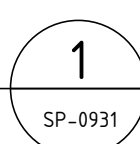

DICKSON ELEVATION

SCALE: 1 : 100 @ A1

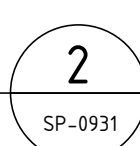

**NOT FOR
CONSTRUCTION**

STAGE 2R - 1

SCALES AT A1 SIZE DRAWING



D	STAGE 2R-1 ISSUE	PJ 10/03	NJ 10/03	KC 10/03
C	STAGE 2 ISSUE	PJ 20/12	NJ 20/12	KC 20/12
B	STAGE 2 ISSUE	PJ 18/11	NJ 18/11	KC 18/11
A	STAGE 1 ISSUE	SV 19/08	NJ 19/08	KC 19/08
AMD	DESCRIPTION	DESIGNER SIGN / DATE	VERIFIED SIGN / DATE	APPROVED SIGN / DATE
CO-ORDINATE SYSTEM: MGA Zone 56		HEIGHT DATUM: A.H.D.	SCALE: 1: 100 @ A1	

DRAWING COLOUR CODED - PRINT ALL COPIES IN COLOUR




*This drawing is confidential and shall only be used for the purpose of this project.
The signing of this title block confirms the design and drafting of this project have been prepared
and checked in accordance with the Architectus quality assurance system to ISO 9001:2008.*

architectus™	DRAWN	HH, KF, KW, PJ, RK, TT	-
	DESIGNED	PHILLIP JI	-
	DRG CHECK	KUSH VEHALLA	-
	DESIGN CHECK	TRENT RUSSELL	-
	APPROVED	KEVIN CARRUCAN	-

CAPITAL METRO PROJECT

PACKAGE 52 - FEDERAL HIGHWAY & NORTHBOURNE AVENUE STOPS
ARCHITECTURAL
DICKSON
ELEVATIONS - SHEET 2

FILE No. 160117	SHEET: 2 OF 3	A
STATUS: STAGE 2R - 1		
DRG No. 02-ARC-DRW-ARC-SP-0982	D	EDMS No.

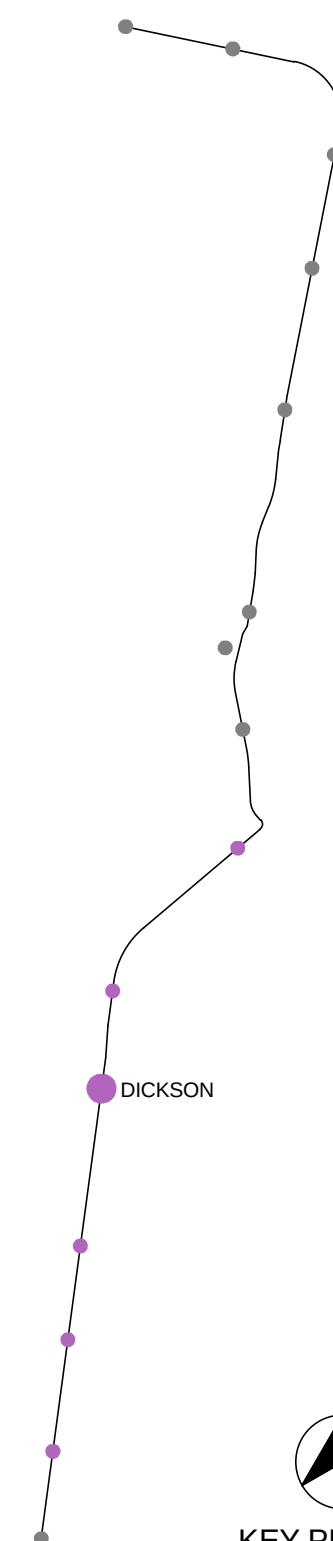


KEY PLAN

File Plotted C:\Revit\160117_Precinct 4-5_richardpilton.rvt

Plot Date & Time 10/03/2017 11:06:00 AM

DF 801*554

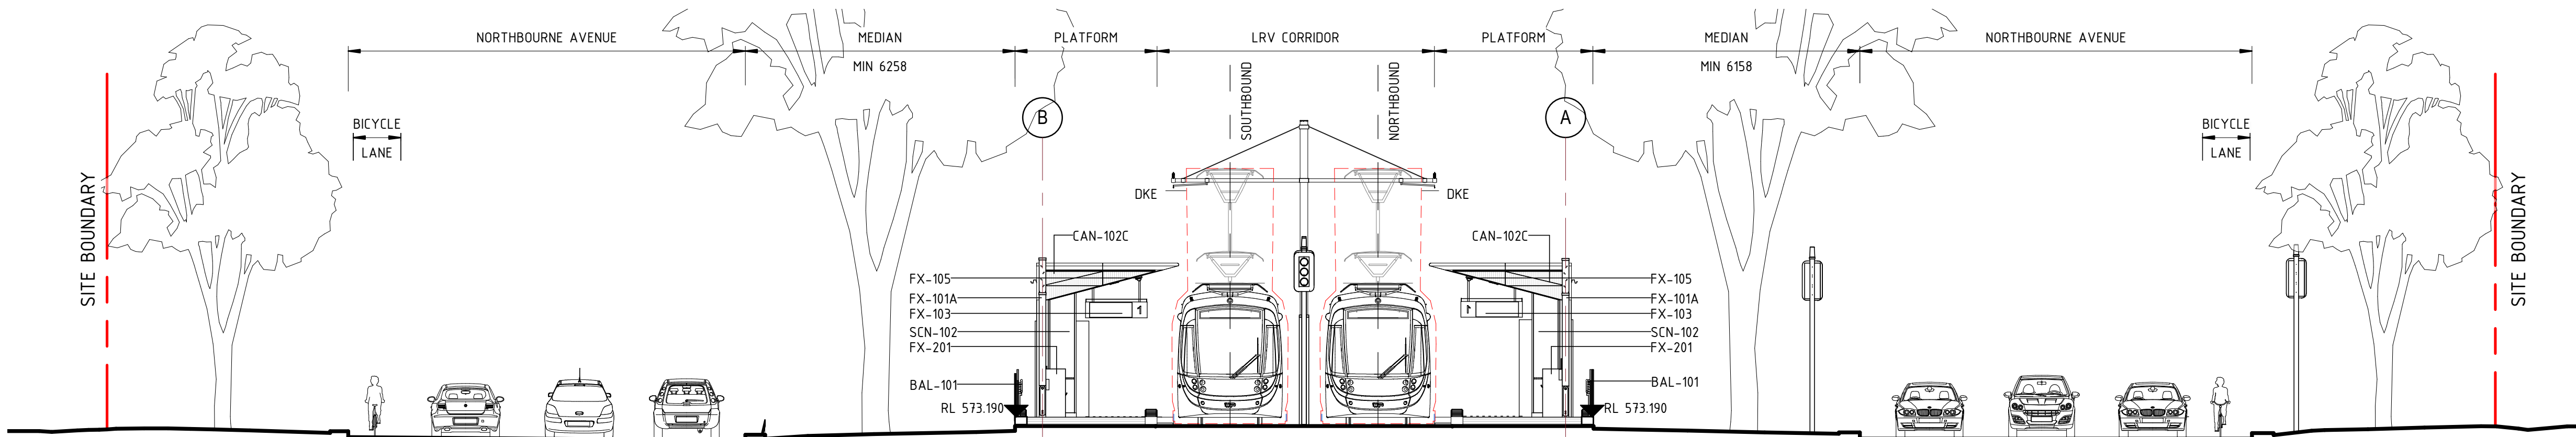


DICKSON ELEVATION

SCALE: 1:100 @ A1

1

SP-0931

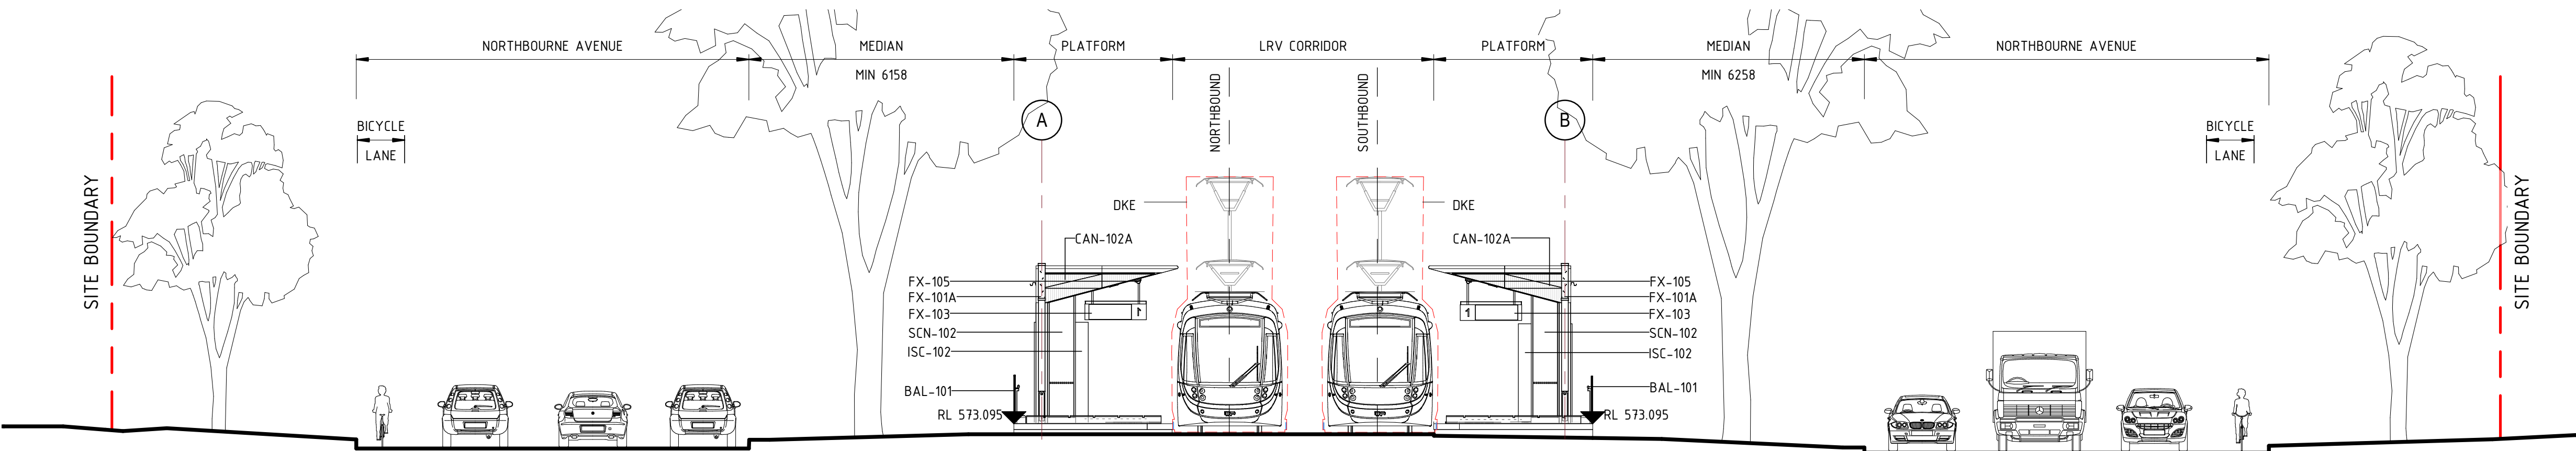

DICKSON ELEVATION

SCALE: 1:100 @ A1


2

SP-0931

**NOT FOR
CONSTRUCTION**

STAGE 2R - 1

 SCALES AT A1 SIZE DRAWING



CO-ORDINATE SYSTEM: MGA Zone 56	HEIGHT DATUM: A.H.D.	SCALE: 1:100 @ A1
D	STAGE 2R-1 ISSUE	PJ 10/03 NJ 10/03 KC 10/03
C	STAGE 2 ISSUE	PJ 20/12 NJ 20/12 KC 20/12
B	STAGE 2 ISSUE	PJ 18/11 NJ 18/11 KC 18/11
A	STAGE 1 ISSUE	SV 19/08 NJ 19/08 KC 19/08
AMD	DESCRIPTION	DESIGNER SIGN / DATE VERIFIED SIGN / DATE APPROVED SIGN / DATE

CapitalMetro
ACT Government

CANBERRA
METRO
Move | Live | Grow


This drawing is confidential and shall only be used for the purpose of this project.
The signing of this title block confirms the design and drafting of this project have been prepared and checked in accordance with the Architectus quality assurance system to ISO 9001-2008.

architectus™


DRAWN _ HH, KF, KW, PJ, RK, TT _
DESIGNED _ PHILLIP JI _
DRG CHECK _ KUSH VEHALLA _
DESIGN CHECK _ TRENT RUSSELL _
APPROVED _ KEVIN CARRUCAN _

CAPITAL METRO PROJECT
PACKAGE 52 - FEDERAL HIGHWAY & NORTHBOURNE AVENUE STOPS
ARCHITECTURAL
DICKSON
ELEVATIONS - SHEET 3

FILE No. 160117 SHEET: 3 OF 3 A1
STATUS: STAGE 2R - 1 ©
DRG No. 02-ARC-DRW-ARC-SP-0983 D EDMS No.

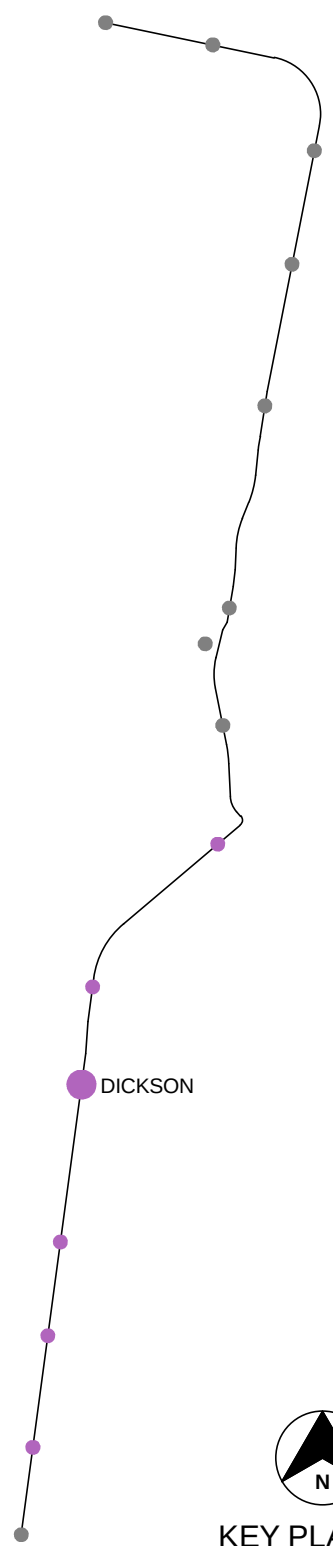


KEY PLAN

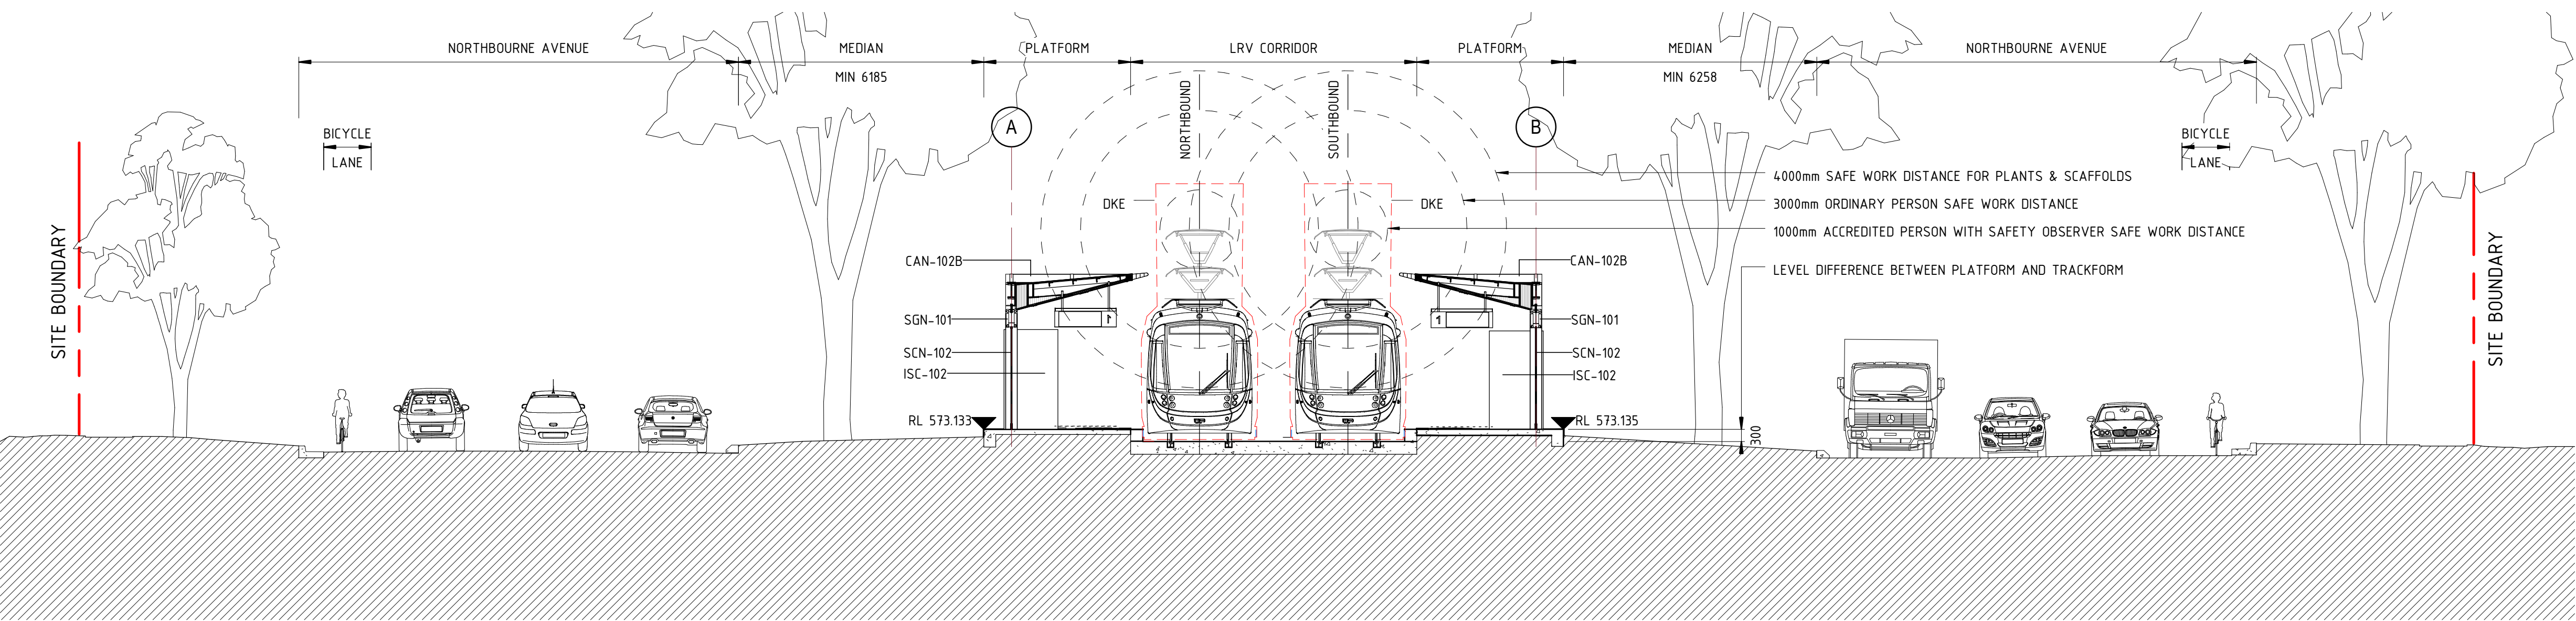

DICKSON SECTION

1
SP-0931


SCALE: 1 : 100 @ A1

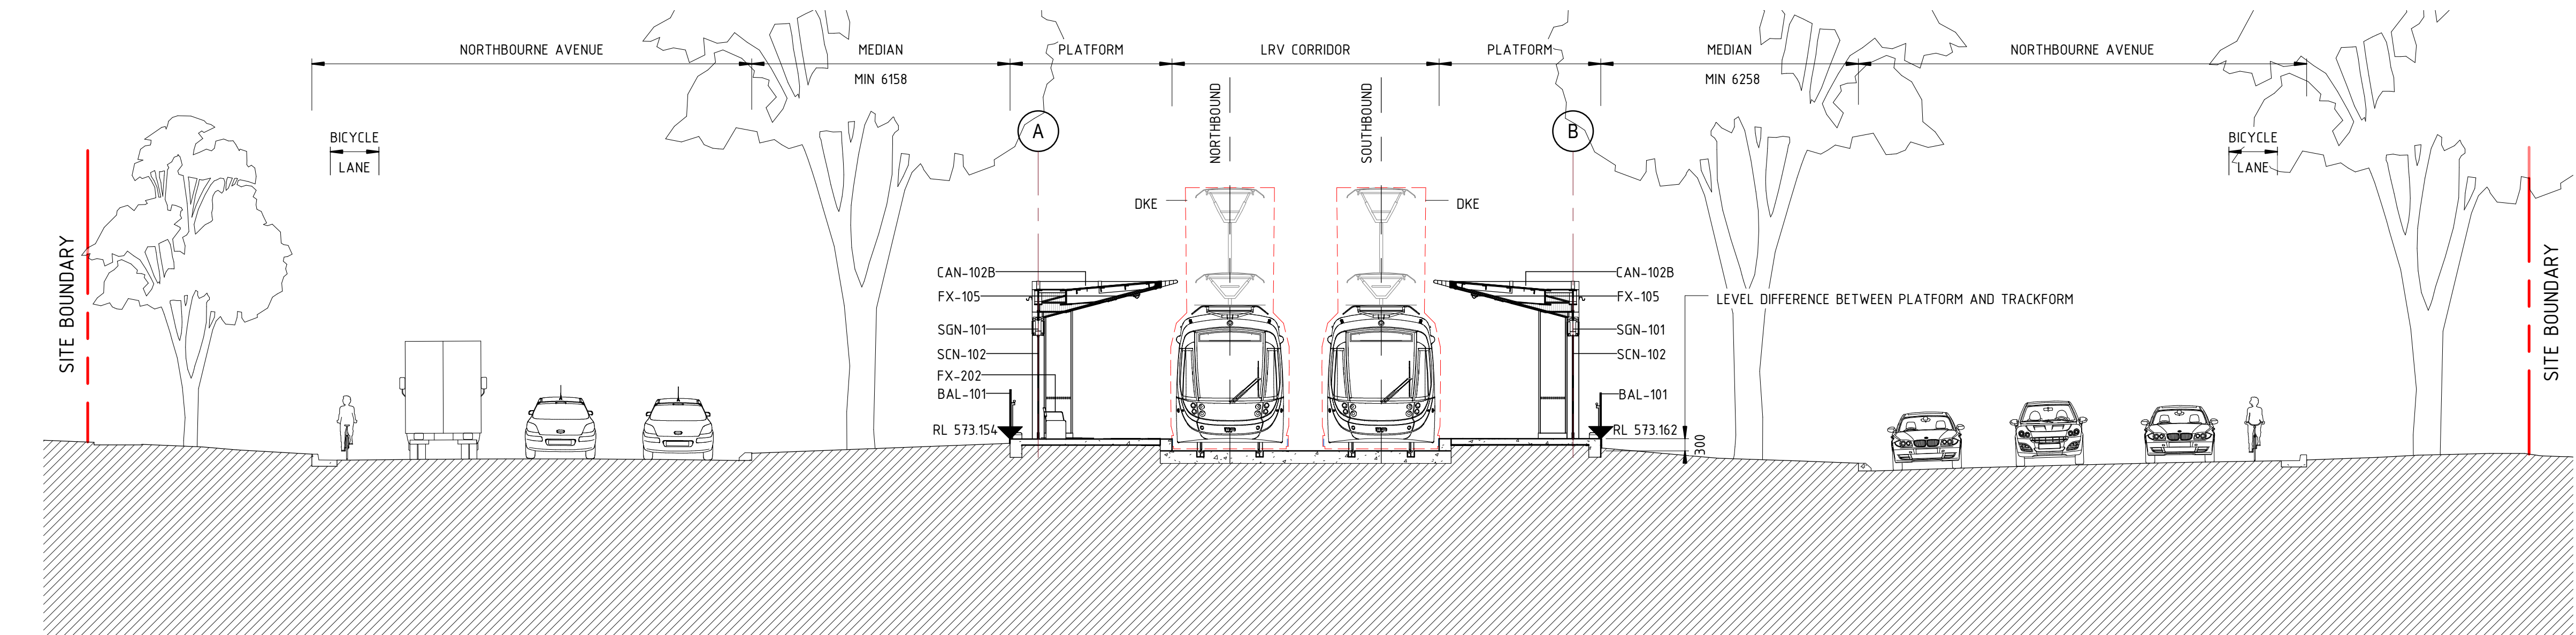

DICKSON SECTION


2
SP-0931

SCALE: 1 : 100 @ A1

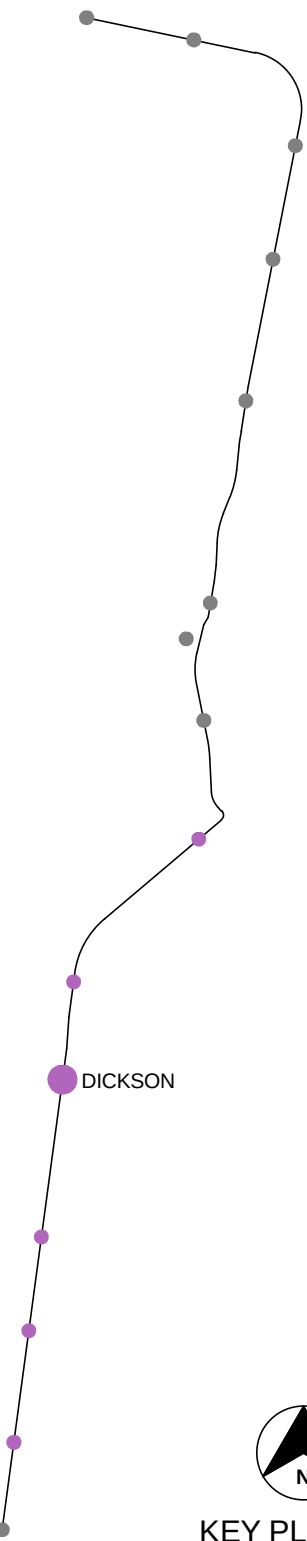

KEY PLAN

**NOT FOR
CONSTRUCTION**
STAGE 2R - 1

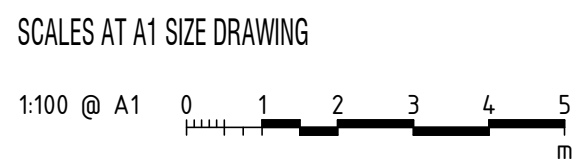

REV	DESCRIPTION	DESIGNER	VERIFIED	APPROVED
D	STAGE 2R-1 ISSUE	PJ 10/03	NJ 10/03	KC 10/03
C	STAGE 2 ISSUE	PJ 20/12	NJ 20/12	KC 20/12
B	STAGE 2 ISSUE	PJ 18/11	NJ 18/11	KC 18/11
A	STAGE 1 ISSUE	SV 19/08	NJ 19/08	KC 19/08
AMD				
CO-ORDINATE SYSTEM: MGA Zone 56		HEIGHT DATUM: A.H.D.		SCALE: 1 : 100 @ A1



This drawing is confidential and shall only be used for the purpose of this project.
The signing of this title block confirms the design and drafting of this project have been prepared and checked in accordance with the Architectus quality assurance system to ISO 9001-2008.

architectus™

DRAWN	HH, KF, KW, PJ, RK, TT	-
DESIGNED	PHILLIP JI	-
DRG CHECK	KUSH VEHALLA	-
DESIGN CHECK	TRENT RUSSELL	-
APPROVED	KEVIN CARRUCAN	-

CAPITAL METRO PROJECT PACKAGE 52 - FEDERAL HIGHWAY & NORTHBOURNE AVENUE STOPS ARCHITECTURAL DICKSON SECTIONS - SHEET 1		
FILE No. 160117	SHEET: 1 OF 1	A1
STATUS: STAGE 2R - 1		©
DRG No. 02-ARC-DRW-ARC-SP-0991	D	EDMS No.